



رَدْعَةُ حُجْرَةٍ مَرْدِيَّةٍ مَرْدِيَّةٍ مَرْدِيَّةٍ مَرْدِيَّةٍ مَرْدِيَّةٍ مَرْدِيَّةٍ مَرْدِيَّةٍ مَرْدِيَّةٍ مَرْدِيَّةٍ مَرْدِيَّةٍ

Tender No.: MWSC-L/1/ADV/2026/15

## Construction of temporary storage site F. Nilandhoo – Second Retender

### Introduction

Male' Water & Sewerage Company Pvt. Ltd, hereby announces Invitation for submission of Proposals to "Construction of temporary storage site F. Nilandhoo."

### Eligibility Criteria

Interested and competent contractors wishing to carry out the above project must submit the following documents with the official quotation/proposal.

### Mandatory Documents:

- Business Registration Certificate.
- Company Profile Information sheet issued by the Ministry of Economic Development
- GST registration certificate (If GST is not registered, please provide a Mira registration copy).
- Declaration of No Conflict of Interest (attached)
- BOQ (attached)

### Registration

To be registered in the tendering process, interested bidders are required to complete the registration through the online link below.

Note: Attending the Pre-bid Information session is **optional**. Bidders who register through the link below will be eligible to submit bids during the bid submission even if they do not attend the Information Session.

**Registration Link:** <https://form.asana.com/?k=amxJ0TkLgP9BgO6TVwPE2w&d=104531750089658>

**The registration deadline is 02<sup>nd</sup> March 2026, 10:00AM**, and late registrations will not be accepted.

The detailed scope of work is included with this document.

### Tender Schedule:

| Step | Process                                   | Date & Time                             | Venue  |
|------|---|---|--|
| 1.   | Pre-bid Information Session               | 26 <sup>th</sup> February 2026, 11:00AM | MWSC CS Building, 6 <sup>th</sup> Floor & F. Nilandhoo Council |
| 2.   | Submission of Proposal & Proposal Opening | 2 <sup>nd</sup> March 2026, 11:00AM     | MWSC CS Building, 6 <sup>th</sup> Floor & F. Nilandhoo Council |


For further information, please contact Procurement Department (+960) 332 3209.

### Procurement Department


Male Water & Sewerage Company Pvt Ltd

24<sup>th</sup> February 2026

F.NILANDHOO

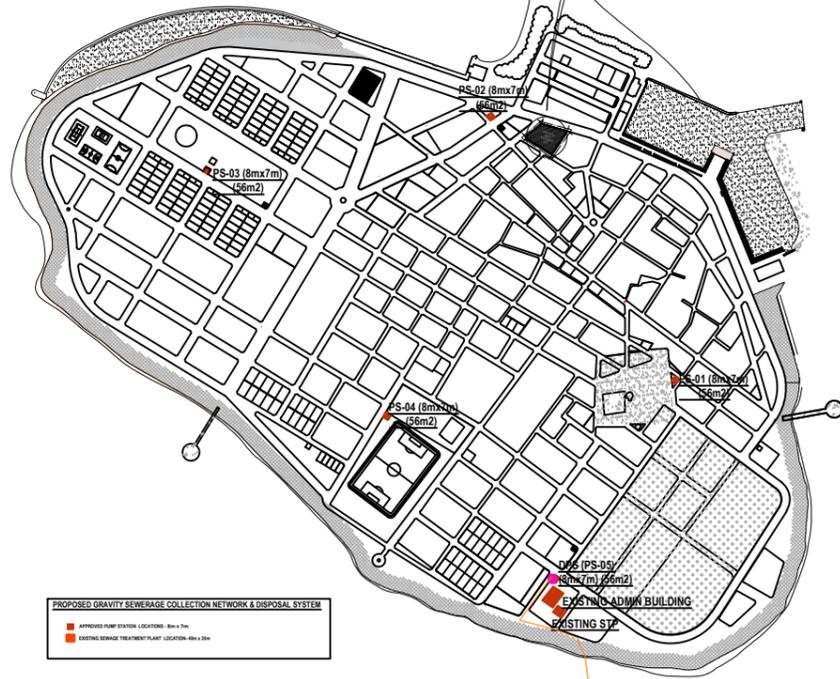

SCALE 1:10

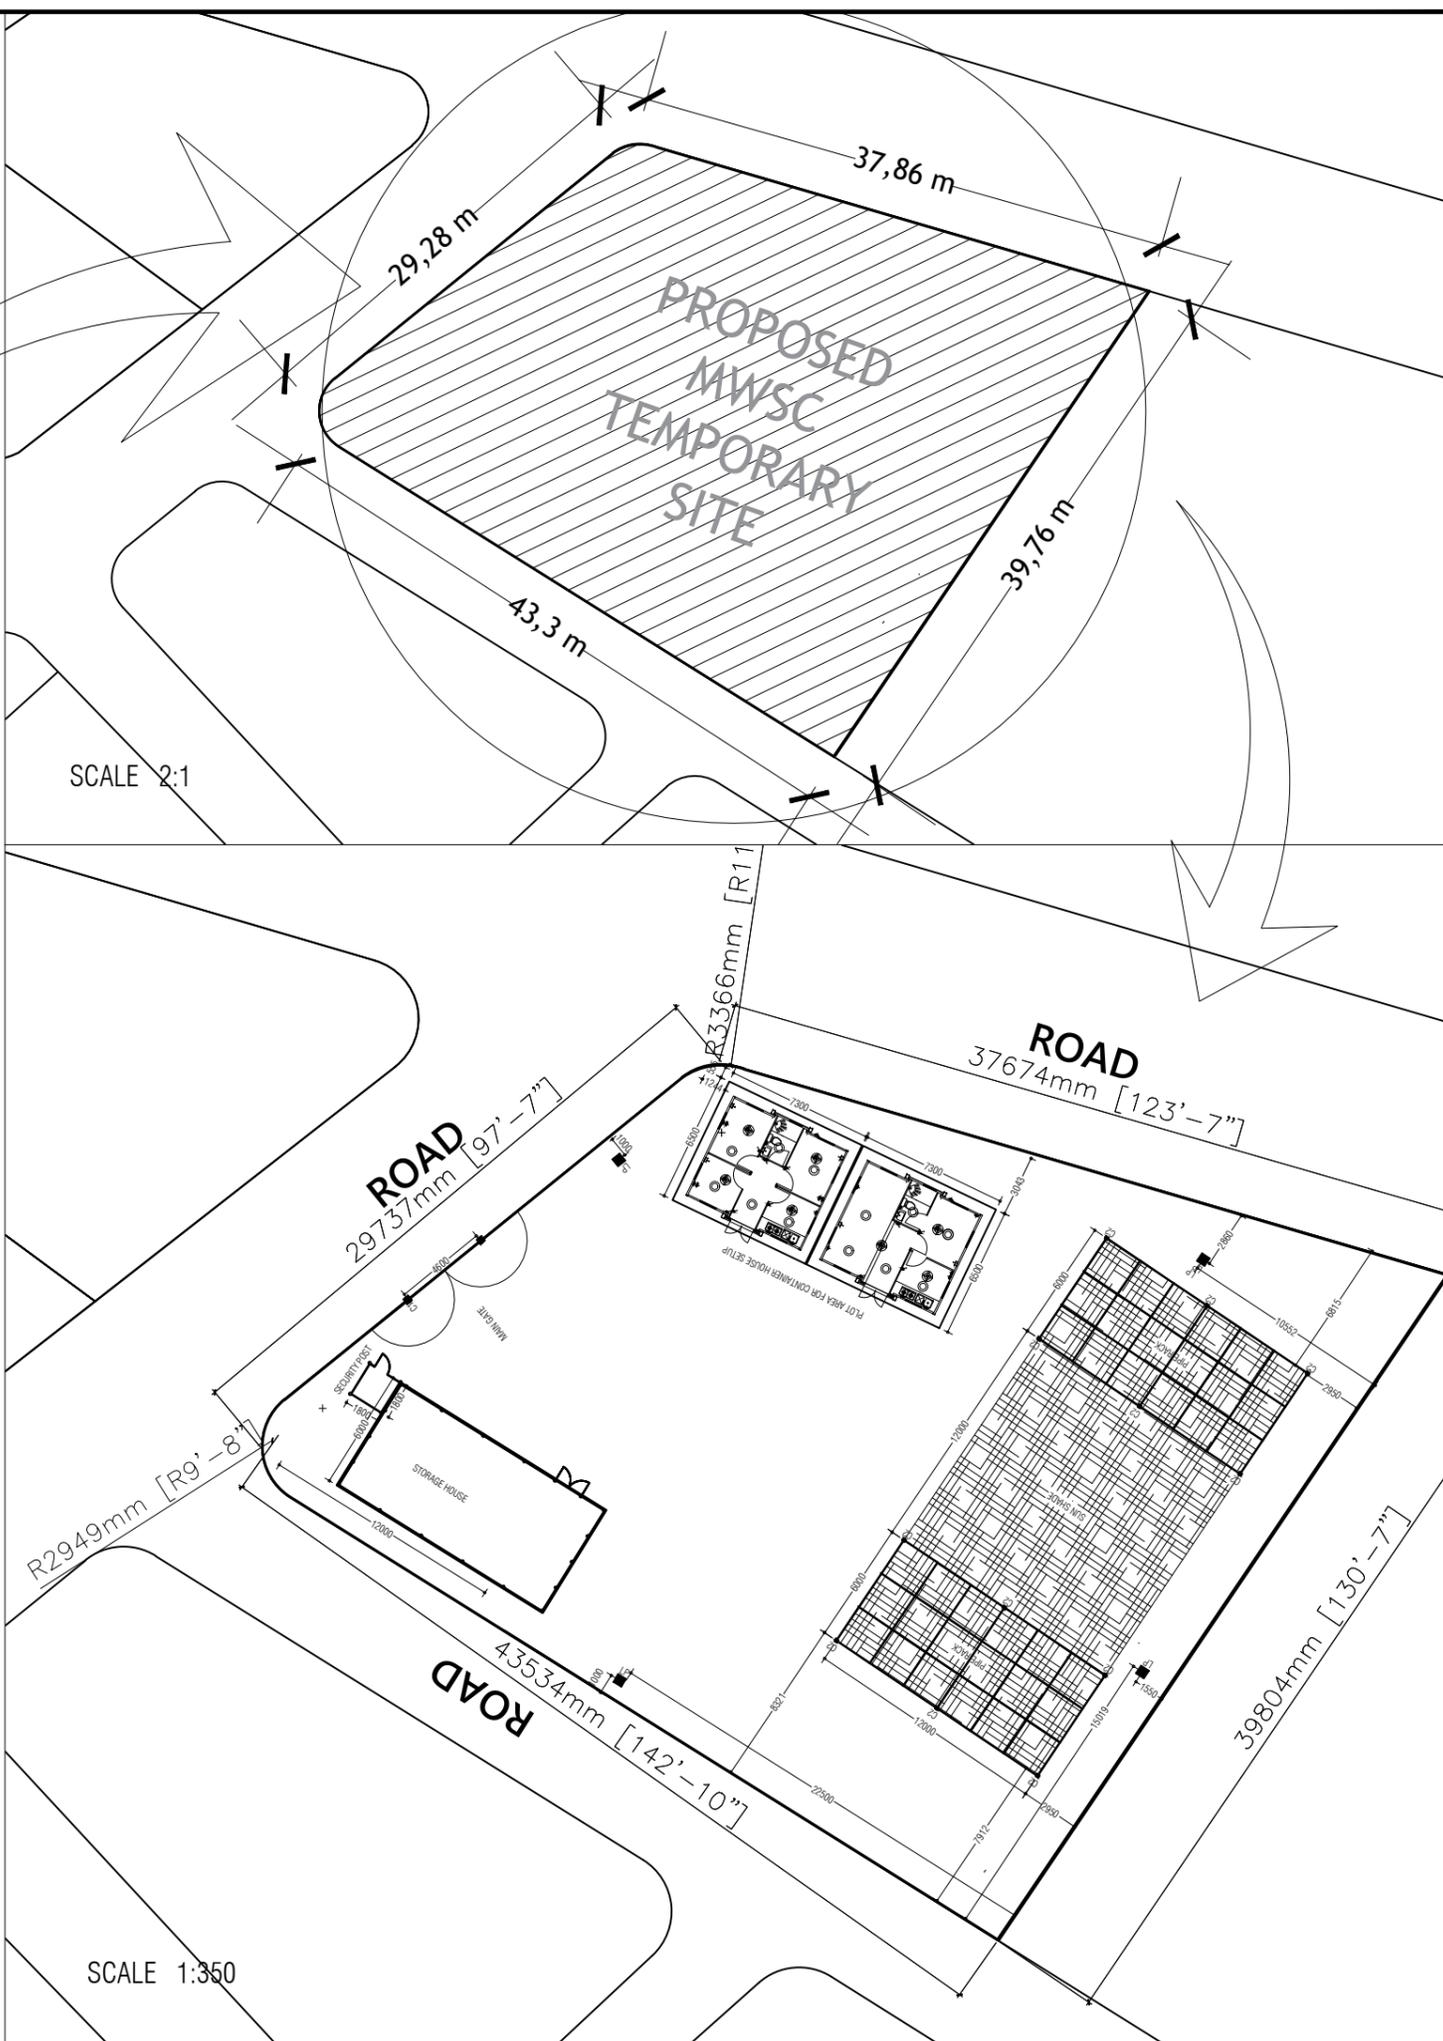

SCALE 2:1

SCALE 1:350

PROJECT TITLE:  
CONSTRUCTION OF DESIGN AND BUILD OF SEWERAGE FACILITIES AT F.NILANDHOO

SUB TITLE:  
SEWERAGE FACILITIES

CLIENT:  
MINISTRY OF CONSTRUCTION,  
HOUSING &  
INFRASTRUCTURE

CONTRACTOR:  
MALE WATER & SEWERAGE  
COMPANY PVT.LTD



DESIGN CONTRACTOR:  
MALE WATER & SEWERAGE  
COMPANY PVT.LTD



TYPE OF DRAWING:  
F.NILANDHOO TEMPORARY SITE

LEGENDS & NOTES:

DRAWN BY: FATHMATH FAZEELA

DRAWING TITLE: F.NILANDHOO TEMPORARY SITE LOCATION

DRAWING NO: 25-E09-NILA-WS-A0-DD-01 PAGE NO: 01

SCALE: AS GIVEN REV NO: 00

DATE: 04th DECEMBER 2025 PAPER SIZE: A3

LOCATION: F.NILANDHOO

ARCHITECT /CHECKER STAMP:

STRUCTURAL ENGINEER /CHECKER STAMP:

ELECTRICAL ENGINEER /CHECKER STAMP:


REVISION DESCRIPTION

REV NO. DATE

REVISION DESCRIPTION

REVISION DESCRIPTION

REVISION DESCRIPTION

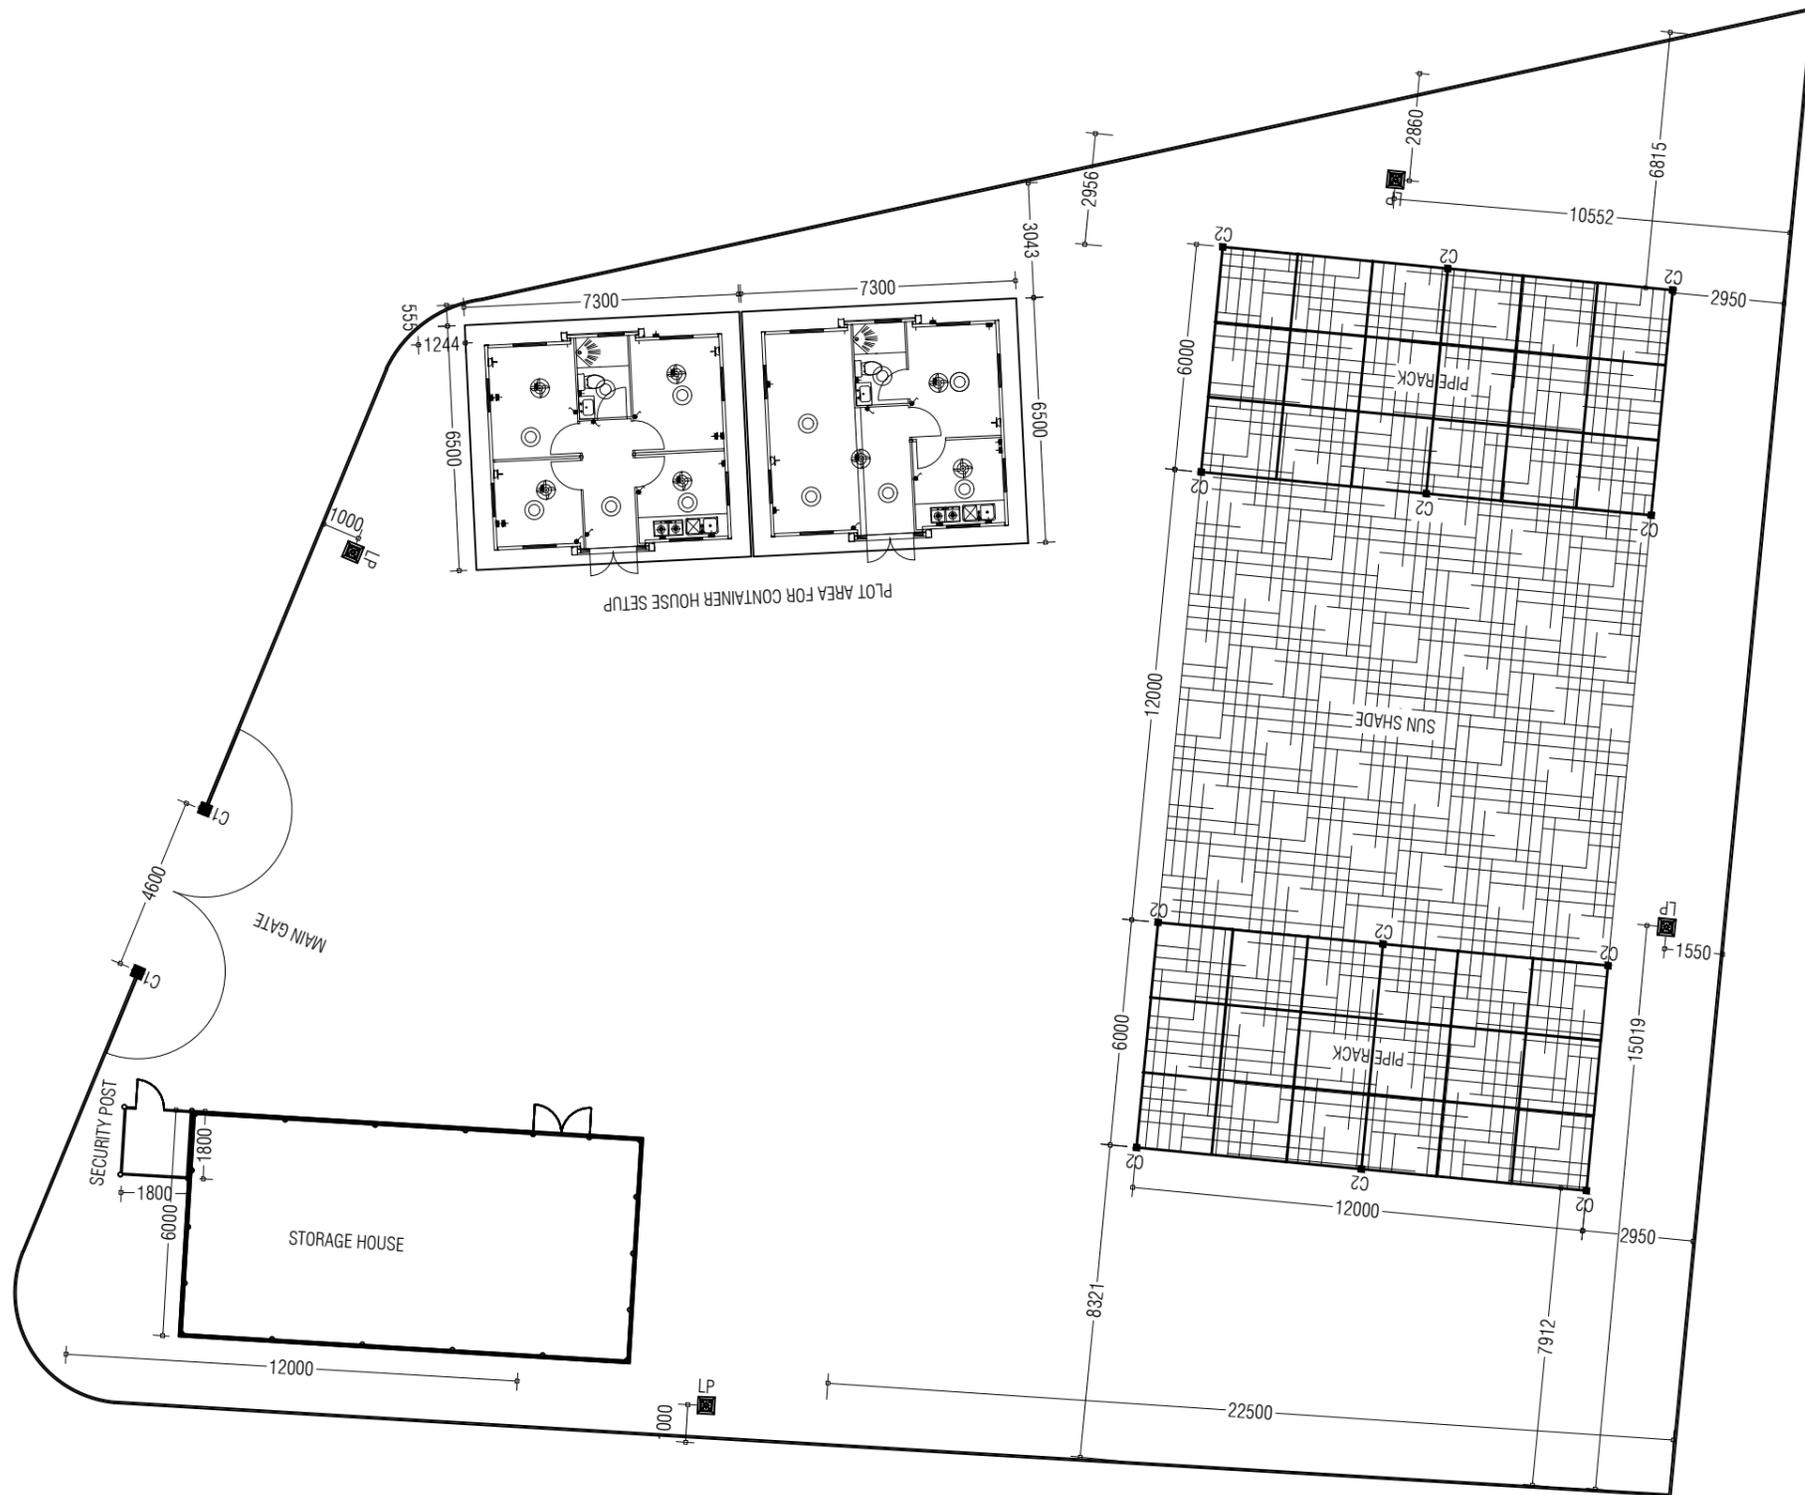

TEMPORARY SITE LAYOUT  
SCALE NTS

PROJECT TITLE:  
CONSTRUCTION OF DESIGN AND BUILD OF SEWERAGE FACILITIES AT F.NILANDHOO

SUB TITLE:  
SEWERAGE FACILITIES

CLIENT:  
MINISTRY OF CONSTRUCTION,  
HOUSING &  
INFRASTRUCTURE

CONTRACTOR:  
MALE' WATER & SEWERAGE  
COMPANY PVT.LTD



DESIGN CONTRACTOR:  
MALE' WATER & SEWERAGE  
COMPANY PVT.LTD



TYPE OF DRAWING: F.NILANDHOO TEMPORARY SITE

LEGENDS & NOTES:

DRAWN BY: FATHMATH FAZEELA

DRAWING TITLE: F.NILANDHOO TEMPORARY SITE LAYOUT

DRAWING NO: 25-E09-NILA-WS-A0-DD-02 PAGE NO: 02

SCALE: NTS REV NO: 00

DATE: 04th DECEMBER 2025 PAPER SIZE: A3

LOCATION: F.NILANDHOO

ARCHITECT /CHECKER STAMP:

STRUCTURAL ENGINEER /CHECKER STAMP:

ELECTRICAL ENGINEER /CHECKER STAMP:

| REV NO. | DATE | REVISION DESCRIPTION |
|---------|------|----------------------|
|         |      |                      |
|         |      |                      |

PROJECT TITLE:  
CONSTRUCTION OF DESIGN AND BUILD OF SEWERAGE  
FACILITIES AT F.NILANDHOO

SUB TITLE:  
SEWERAGE FACILITIES

CLIENT:  
MINISTRY OF CONSTRUCTION,  
HOUSING &  
INFRASTRUCTURE

CONTRACTOR:  
MALE WATER & SEWERAGE  
COMPANY PVT.LTD




DESIGN CONTRACTOR:  
MALE WATER & SEWERAGE  
COMPANY PVT.LTD




TYPE OF  
DRAWING: F.NILANDHOO TEMPORARY SITE

LEGENDS & NOTES:

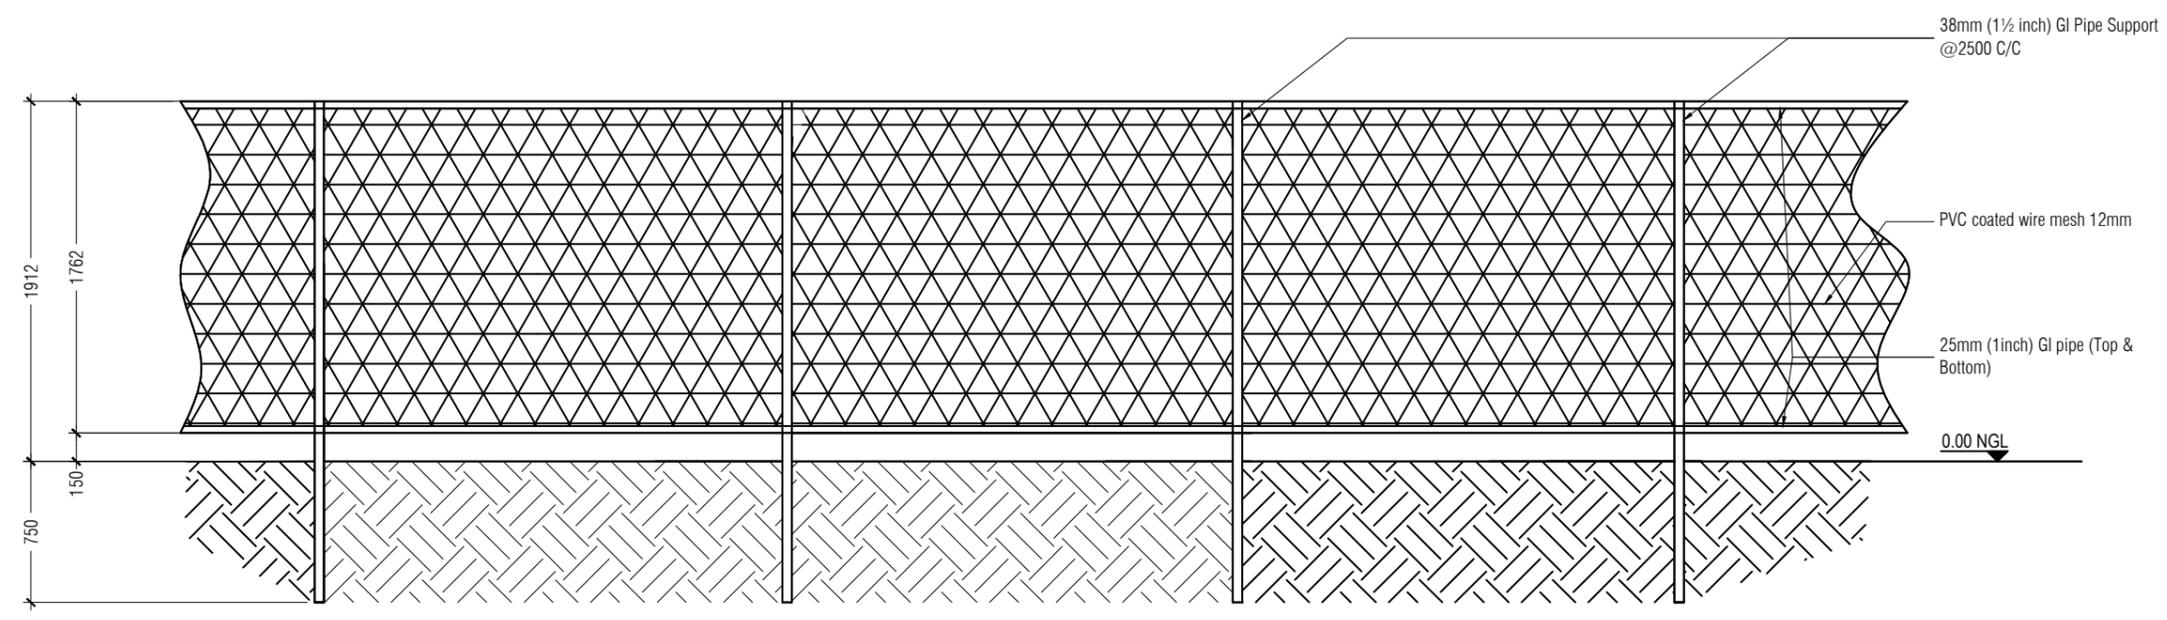

BOUNDARY FENCE DETAILS  
SCALE NTS

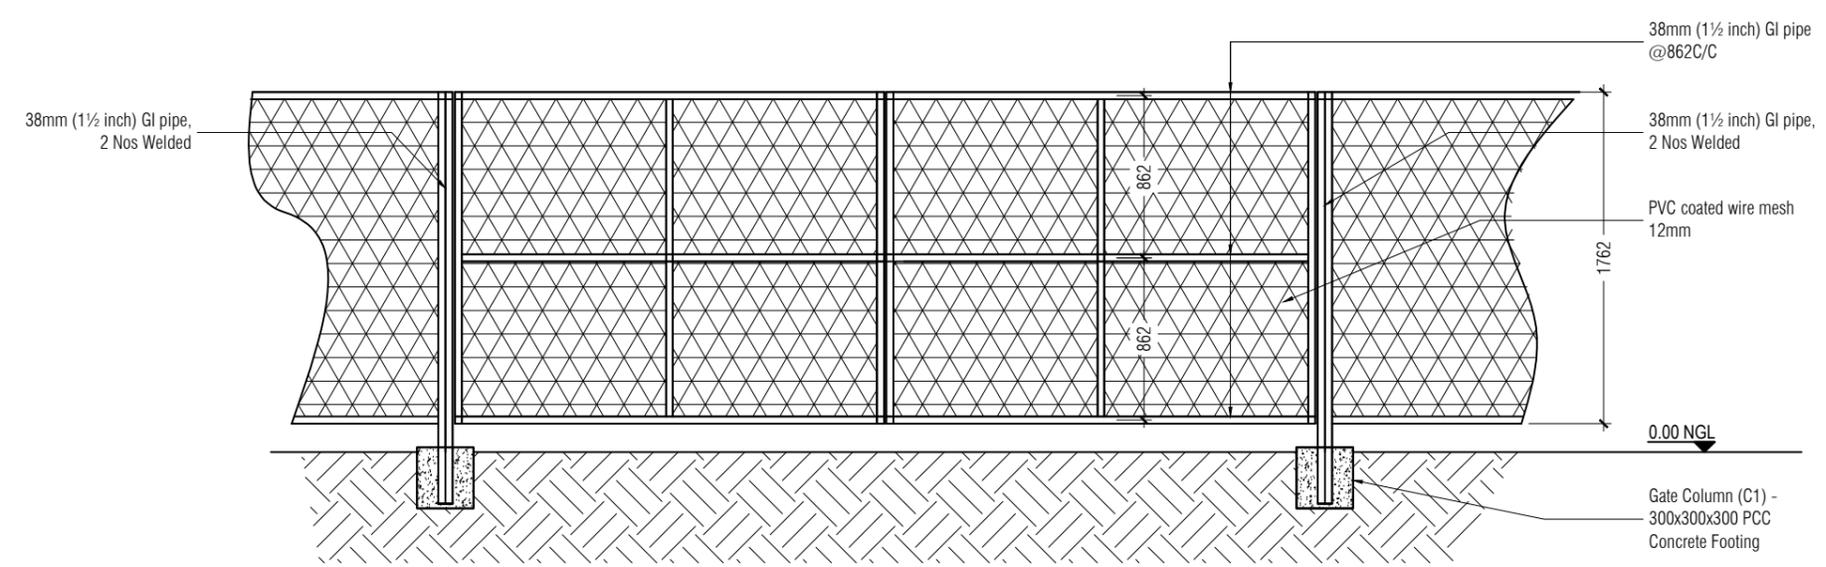

Note: Required hinges and locking system should be provided for the Gate

BOUNDARY GATE DETAILS  
SCALE NTS

DRAWN BY: FATHMATH FAZEELA

DRAWING TITLE: BOUNDARY FENCE & GATE DETAILS

DRAWING NO: 25-E09-NILA-WS-D1-DD-03 PAGE NO: 03

SCALE: NTS REV NO: 00

DATE: 04th DECEMBER 2025 PAPER SIZE: A3


LOCATION: F.NILANDHOO

ARCHITECT  
/CHECKER  
STAMP:

STRUCTURAL  
ENGINEER  
/CHECKER  
STAMP:

ELECTRICAL  
ENGINEER  
/CHECKER  
STAMP:

| REV NO. | DATE | REVISION DESCRIPTION |
|---------|------|----------------------|
|         |      |                      |
|         |      |                      |

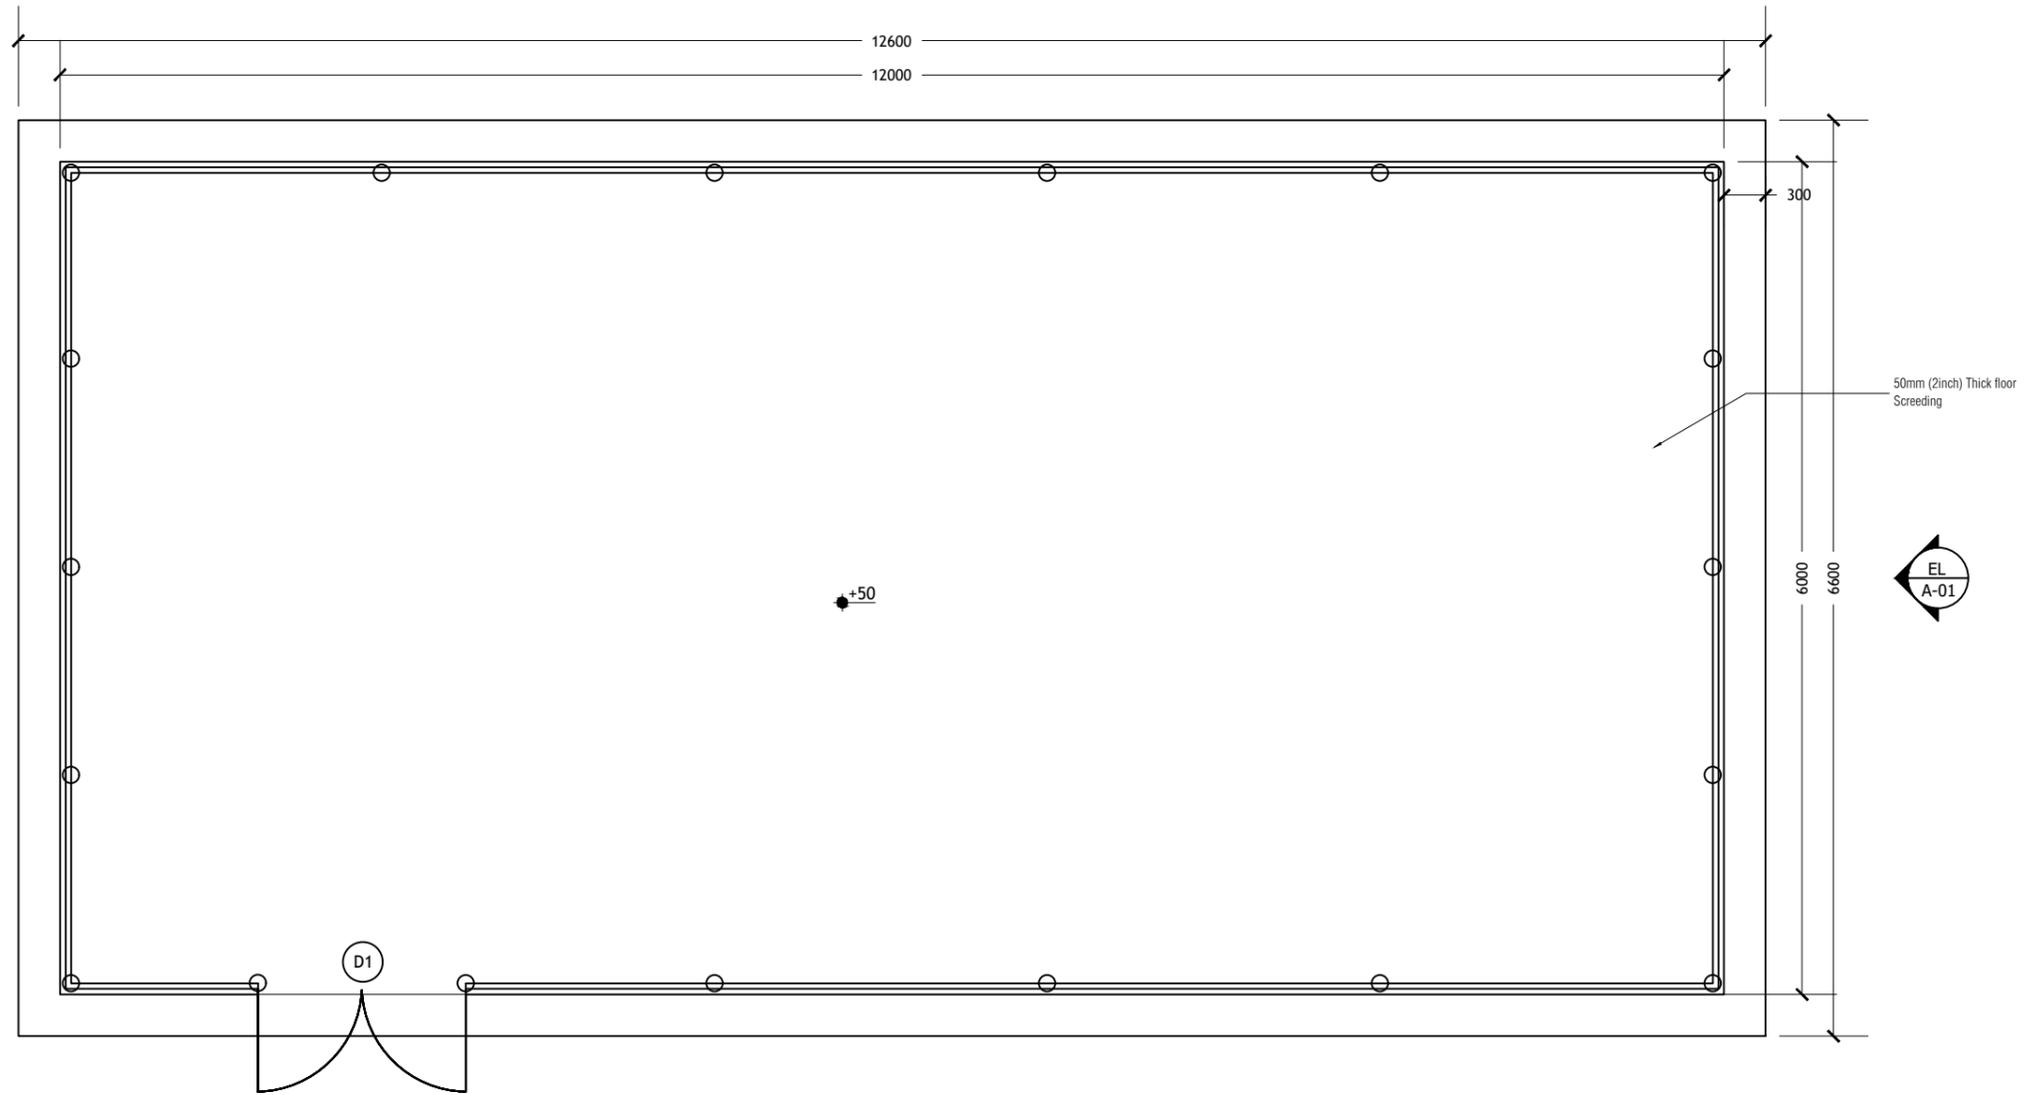

STORAGE HOUSE - FLOOR LAYOUT  
SCALE NTS

PROJECT TITLE:  
CONSTRUCTION OF DESIGN AND BUILD OF SEWERAGE FACILITIES AT F.NILANDHOO

SUB TITLE:  
SEWERAGE FACILITIES

CLIENT:  
MINISTRY OF CONSTRUCTION,  
HOUSING &  
INFRASTRUCTURE

CONTRACTOR:  
MALE WATER & SEWERAGE  
COMPANY PVT.LTD



DESIGN CONTRACTOR:  
MALE WATER & SEWERAGE  
COMPANY PVT.LTD



TYPE OF DRAWING:  
F.NILANDHOO TEMPORARY SITE

LEGENDS & NOTES:

DRAWN BY: FATHMATH FAZEELA

DRAWING TITLE: STORAGE HOUSE FLOOR LAYOUT

DRAWING NO: 25-E09-NILA-WS-A1-DD-04 PAGE NO: 04

SCALE: NTS REV NO: 00

DATE: 04th DECEMBER 2025 PAPER SIZE: A3

LOCATION: F.NILANDHOO

ARCHITECT  
/CHECKER  
STAMP:

STRUCTURAL  
ENGINEER  
/CHECKER  
STAMP:

ELECTRICAL  
ENGINEER  
/CHECKER  
STAMP:

| REV NO. | DATE | REVISION DESCRIPTION |
|---------|------|----------------------|
|         |      |                      |
|         |      |                      |

PROJECT TITLE:  
CONSTRUCTION OF DESIGN AND BUILD OF SEWERAGE  
FACILITIES AT F.NILANDHOO

SUB TITLE:  
SEWERAGE FACILITIES

CLIENT:  
MINISTRY OF CONSTRUCTION,  
HOUSING &  
INFRASTRUCTURE

CONTRACTOR:  
MALE' WATER & SEWERAGE  
COMPANY PVT.LTD



DESIGN CONTRACTOR:  
MALE' WATER & SEWERAGE  
COMPANY PVT.LTD




TYPE OF  
DRAWING: F.NILANDHOO TEMPORARY SITE


LEGENDS & NOTES:

Electrical Symbols Key:

- LED Flood Light 50W
- 2 Gang light control Switch
- D- Board

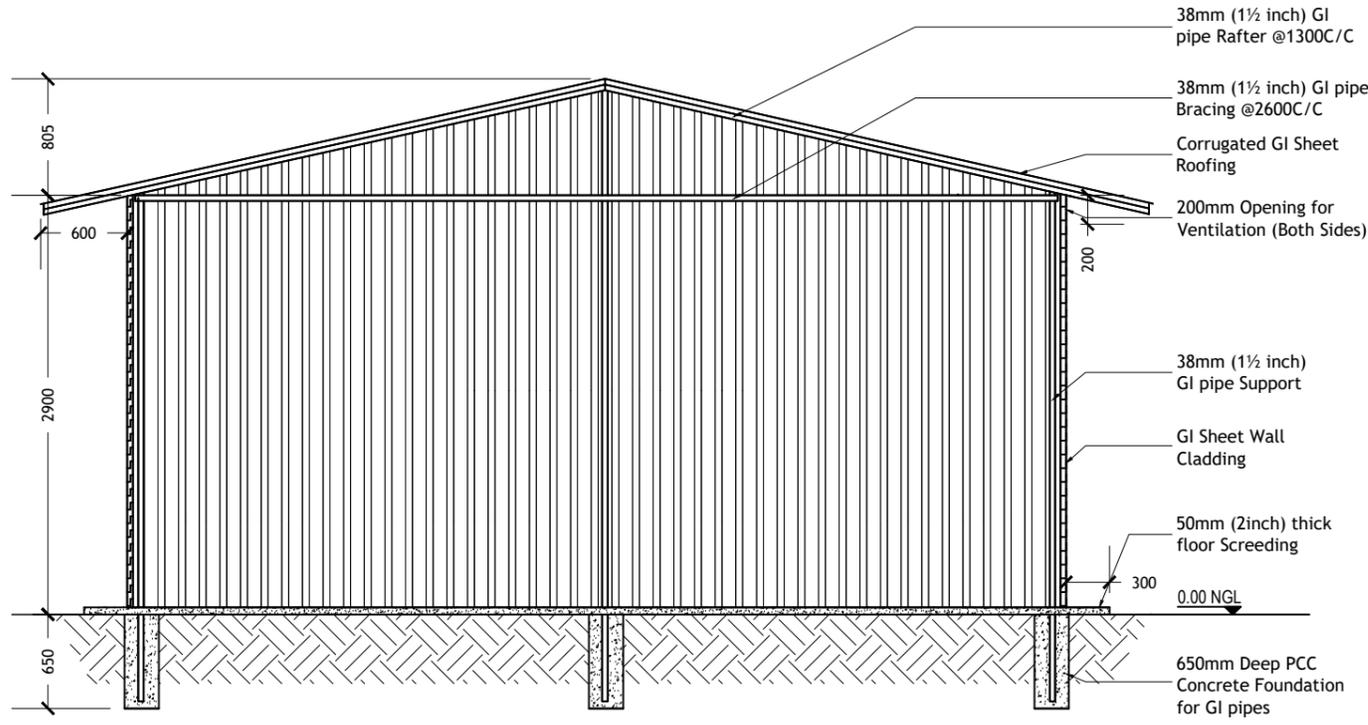


STORAGE HOUSE - ELEVATION A01  
SCALE NTS

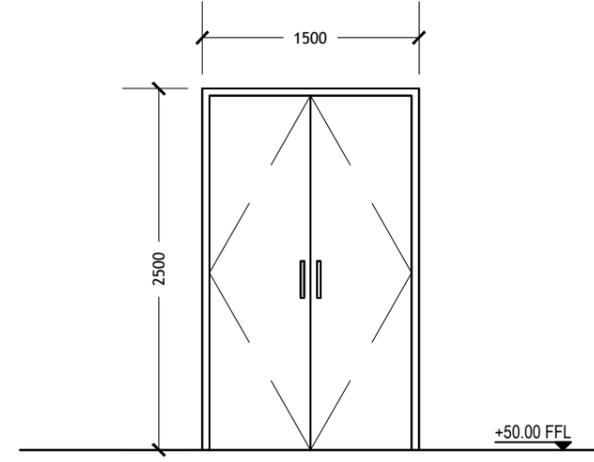

|          |   |
|----------|---|
| D1       | DOUBLE LEAF SWING TYPE DOOR                 |
| REMARKS  | CLADDING SHEET WITH GI 38ØMM FRAME          |
| QUANTITY | 01 NOS                                      |
| HARDWARE | 8 NOS HINGES<br>1 LOCK SET<br>1 LOCK HANDLE |

STORAGE HOUSE - DOOR DETAILS  
SCALE NTS

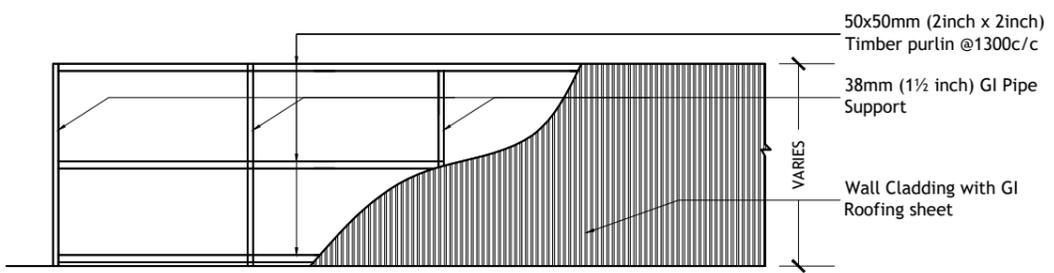

STORAGE HOUSE - WALL CLADDING DETAILS  
SCALE NTS

DRAWN BY: FATHMATH FAZEELA

DRAWING TITLE: STORAGE HOUSE ELEVATION WALL CLADDING & DOOR DETAILS

DRAWING NO: 25-E09-NILA-WS-D1-DD-05 PAGE NO: 05

SCALE: AS GIVEN REV NO: 00

DATE: 04th DECEMBER 2025 PAPER SIZE: A3

LOCATION: F.NILANDHOO

ARCHITECT /CHECKER STAMP:

STRUCTURAL ENGINEER /CHECKER STAMP:

ELECTRICAL ENGINEER /CHECKER STAMP:

| REV NO. | DATE | REVISION DESCRIPTION |
|---------|------|----------------------|
|         |      |                      |
|         |      |                      |

PROJECT TITLE:  
CONSTRUCTION OF DESIGN AND BUILD OF SEWERAGE FACILITIES AT F.NILANDHOO

SUB TITLE:  
SEWERAGE FACILITIES

CLIENT:  
MINISTRY OF CONSTRUCTION,  
HOUSING &  
INFRASTRUCTURE

CONTRACTOR:  
MALE WATER & SEWERAGE  
COMPANY PVT.LTD




DESIGN CONTRACTOR:  
MALE WATER & SEWERAGE  
COMPANY PVT.LTD



TYPE OF DRAWING: F.NILANDHOO TEMPORARY SITE

LEGENDS & NOTES:

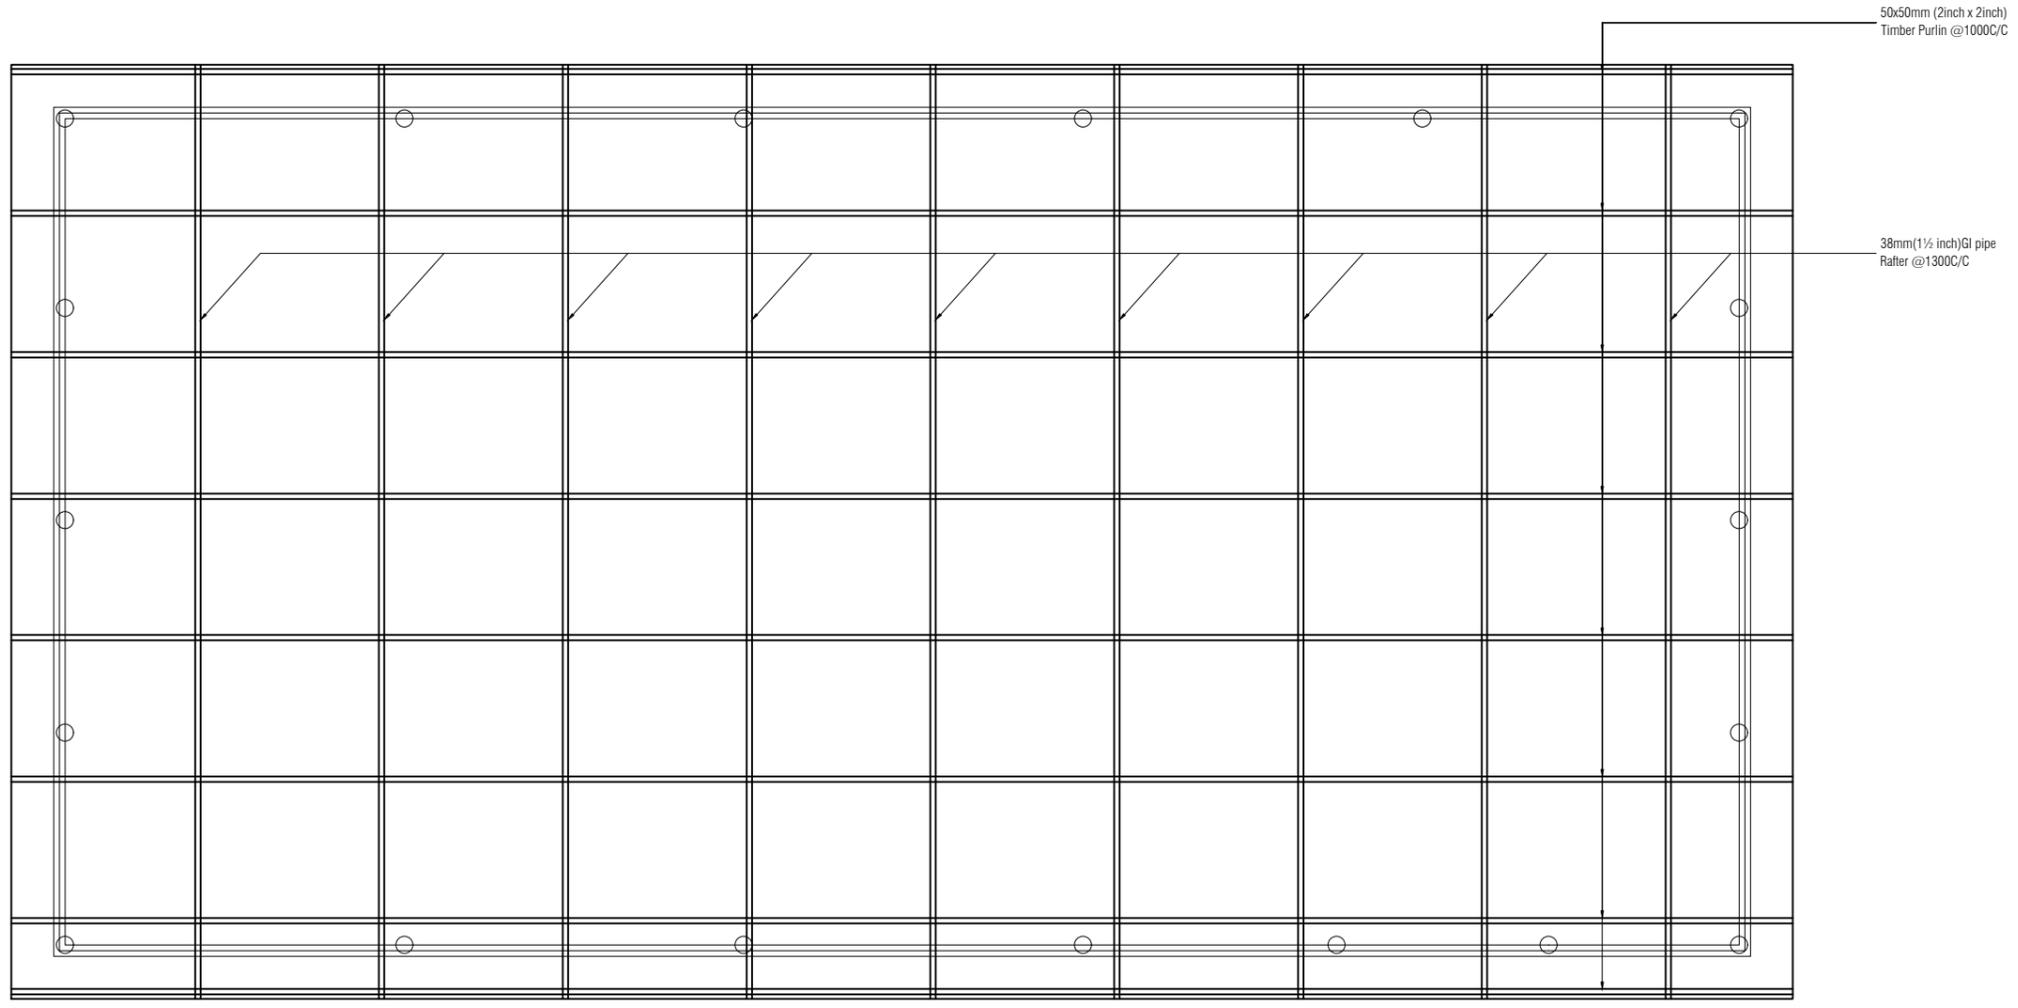

50x50mm (2inch x 2inch)  
Timber Purlin @1000C/C

38mm(1½ inch)GI pipe  
Rafter @1300C/C

STORAGE HOUSE - ROOF FRAME DETAILS  
SCALE NTS

DRAWN BY: FATHMATH FAZEELA

DRAWING TITLE: STORAGE HOUSE ROOF FRAME DETAILS

DRAWING NO: 25-E09-NILA-WS-D1-DD-06 PAGE NO: 06

SCALE: NTS REV NO: 00

DATE: 04th DECEMBER 2025 PAPER SIZE: A3

LOCATION: N.LANDHOO

ARCHITECT  
/CHECKER  
STAMP:

STRUCTURAL  
ENGINEER  
/CHECKER  
STAMP:

ELECTRICAL  
ENGINEER  
/CHECKER  
STAMP:

| REV NO. | DATE | REVISION DESCRIPTION |
|---------|------|----------------------|
|         |      |                      |
|         |      |                      |

PROJECT TITLE:  
CONSTRUCTION OF DESIGN AND BUILD OF SEWERAGE FACILITIES AT F.NILANDHOO

SUB TITLE:  
SEWERAGE FACILITIES

CLIENT:  
MINISTRY OF CONSTRUCTION,  
HOUSING &  
INFRASTRUCTURE

CONTRACTOR:  
MALE WATER & SEWERAGE  
COMPANY PVT.LTD



DESIGN CONTRACTOR:  
MALE WATER & SEWERAGE  
COMPANY PVT.LTD



TYPE OF DRAWING: F.NILANDHOO TEMPORARY SITE

LEGENDS & NOTES:

DRAWN BY: FATHMATH FAZEELA

DRAWING TITLE: STORAGE HOUSE ELECTRICAL LAYOUT

DRAWING NO: 25-E09-NILA-WS-E01-DD-07 PAGE NO: 07

SCALE: NTS REV NO: 00

DATE: 04th DECEMBER 2025 PAPER SIZE: A3

LOCATION: N.LANDHOO

ARCHITECT /CHECKER STAMP:


STRUCTURAL ENGINEER /CHECKER STAMP:

ELECTRICAL ENGINEER /CHECKER STAMP:

| REV NO. | DATE | REVISION DESCRIPTION |
|---------|------|----------------------|
|         |      |                      |
|         |      |                      |

**LEGEND**

-  D-Board
-  LED Flood Light 50W
-  1 Gang Light Control Switch
-  2 Gang Light Control Switch
-  3 Gang Light Control Switch
-  4 Gang Light Control Switch

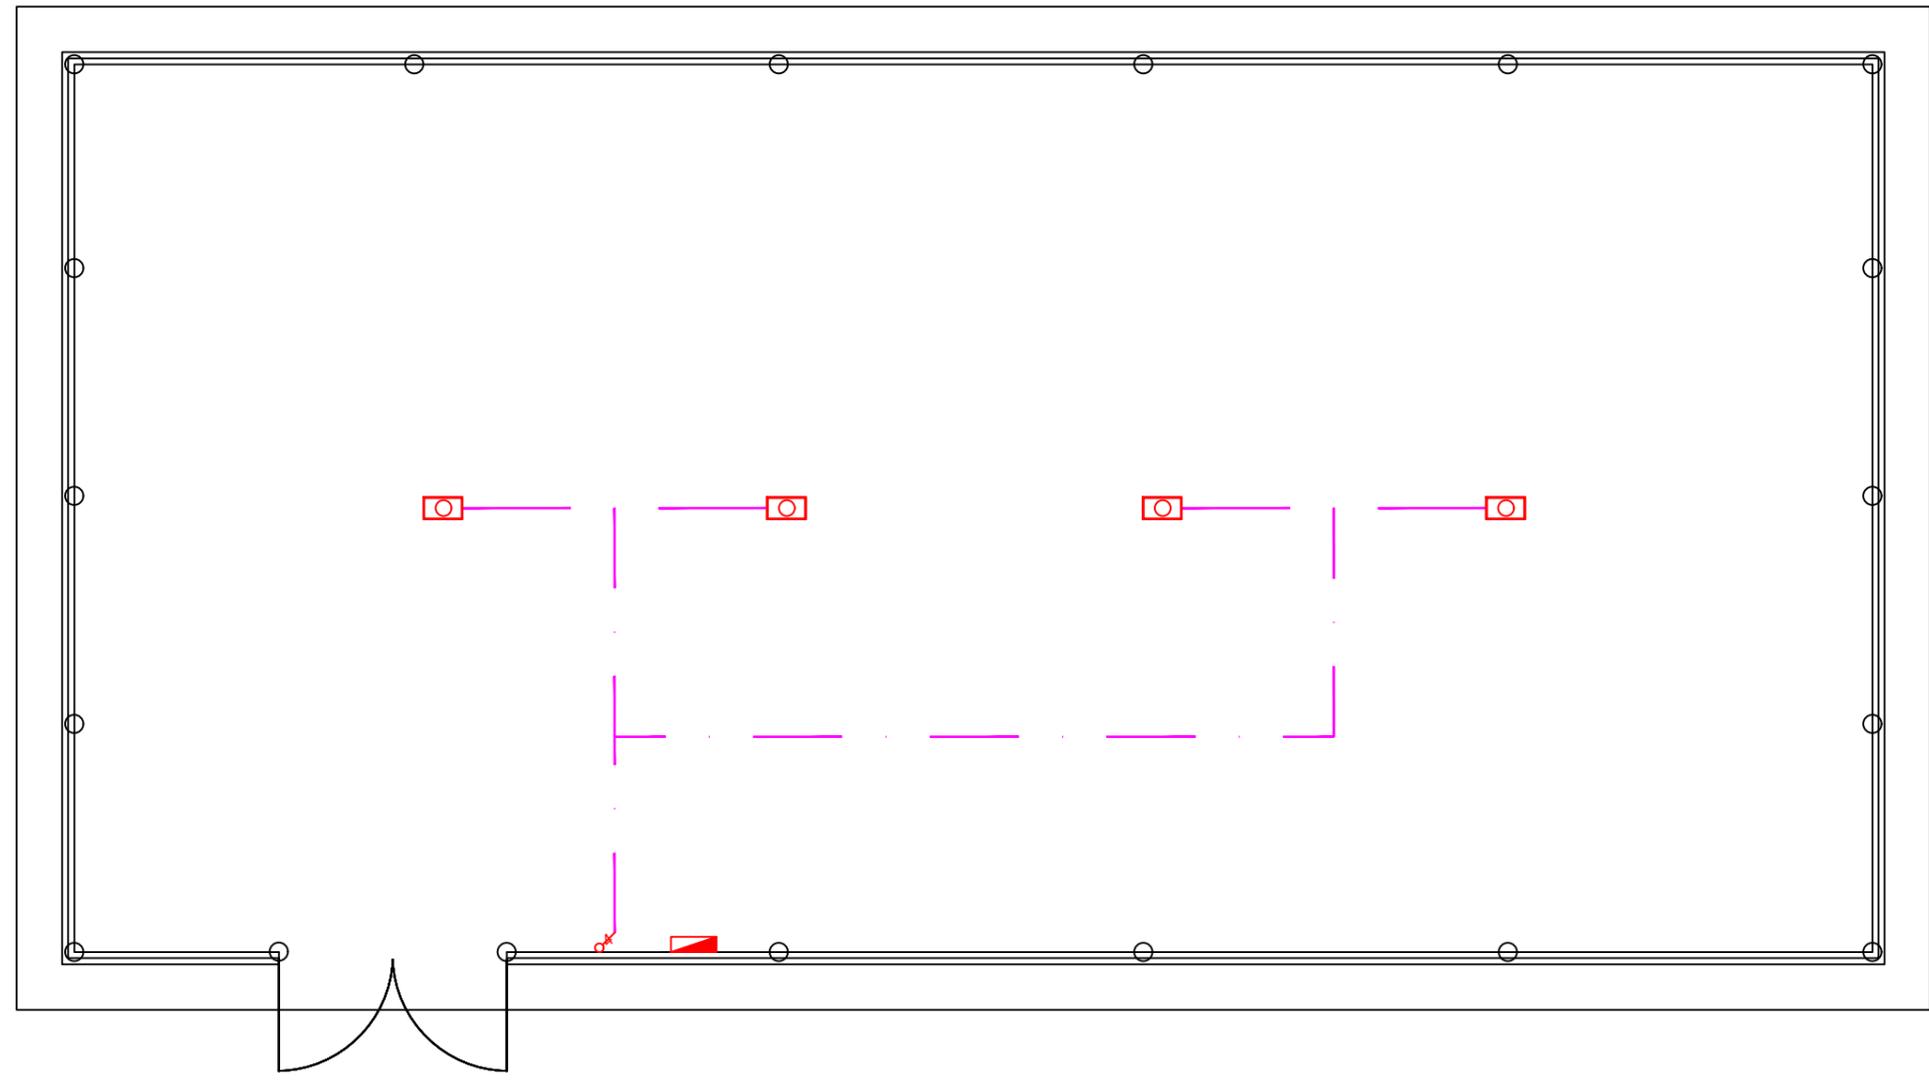

STORAGE HOUSE - ELECTRICAL LAYOUT  
SCALE NTS



LEGENDS & NOTES:

Electrical Symbols Key:

- Wall Mount Light
- Light control Switch
- Fan Dimmer Switch
- D- Board
- Ceiling Mounted Fan
- Light post switch

DRAWN BY: FATHMATH FAZEELA

DRAWING TITLE: SECURITY POST DETAILS

DRAWING NO: 25-E09-NILA-WS-D1-DD-08 PAGE NO: 08

SCALE: NTS REV NO: 00

DATE: 04th DECEMBER 2025 PAPER SIZE: A3

LOCATION: N.LANDHOO

ARCHITECT /CHECKER STAMP:

STRUCTURAL ENGINEER /CHECKER STAMP:

ELECTRICAL ENGINEER /CHECKER STAMP:

| REV NO. | DATE | REVISION DESCRIPTION |
|---------|------|----------------------|
|         |      |                      |
|         |      |                      |

**LEGEND**

Wall Mount Light

D-Board

Ceiling Mounted Fan


1 Gang Light Control Switch

2 Gang Light Control Switch


3 Gang Light Control Switch

4 Gang Light Control Switch


Fan Dimmer Switch

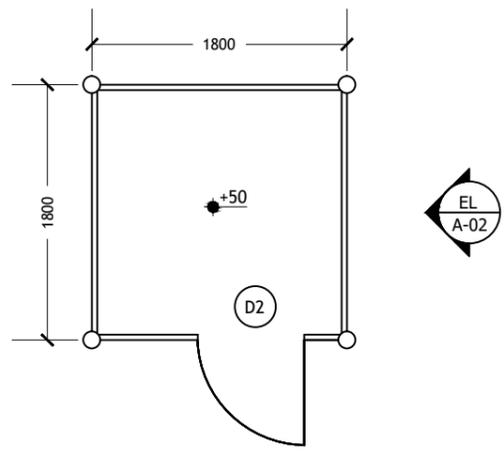


SECURITY POST - FLOOR LAYOUT  
SCALE NTS

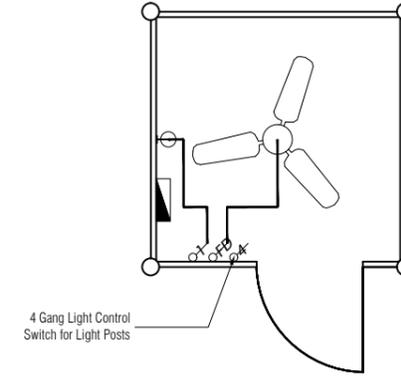

SECURITY POST - ELECTRICAL LAYOUT  
SCALE NTS

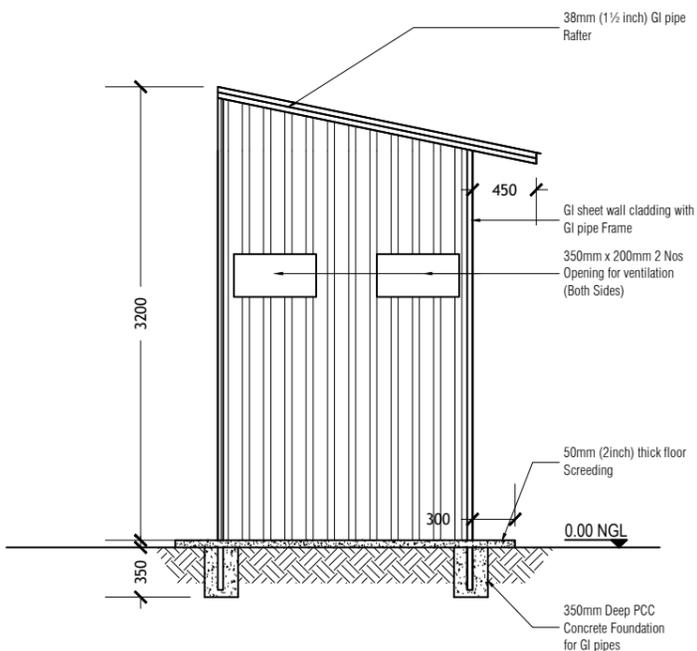

SECURITY POST - ELEVATION A02  
SCALE NTS

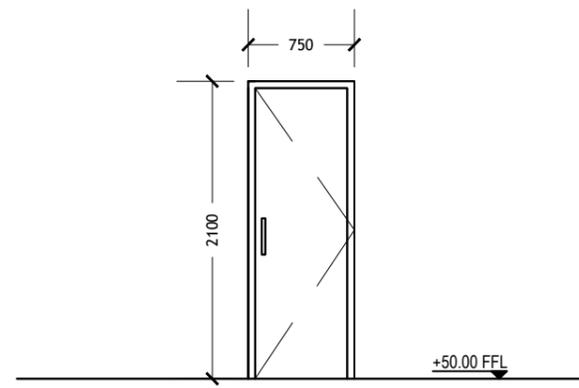

|          |   |
|----------|---|
| D2       | SINGLE LEAF SWING TYPE DOOR                         |
| REMARKS  | CLADDING SHEET WITH GI 38ØMM FRAME OR TIMBER FRAME  |
| QUANTITY | 01 NOS  |
| HARDWARE | 4 NOS HINGES<br>1 NOS LOCK SET<br>1 NOS LOCK HANDLE |

SECURITY POST - DOOR DETAILS  
SCALE NTS

PROJECT TITLE:  
CONSTRUCTION OF DESIGN AND BUILD OF SEWERAGE  
FACILITIES AT F.NILANDHOO

SUB TITLE:  
SEWERAGE FACILITIES

CLIENT:  
MINISTRY OF CONSTRUCTION,  
HOUSING &  
INFRASTRUCTURE

CONTRACTOR:  
MALE WATER & SEWERAGE  
COMPANY PVT.LTD




DESIGN CONTRACTOR:  
MALE WATER & SEWERAGE  
COMPANY PVT.LTD



TYPE OF  
DRAWING: F.NILANDHOO TEMPORARY SITE

LEGENDS & NOTES:

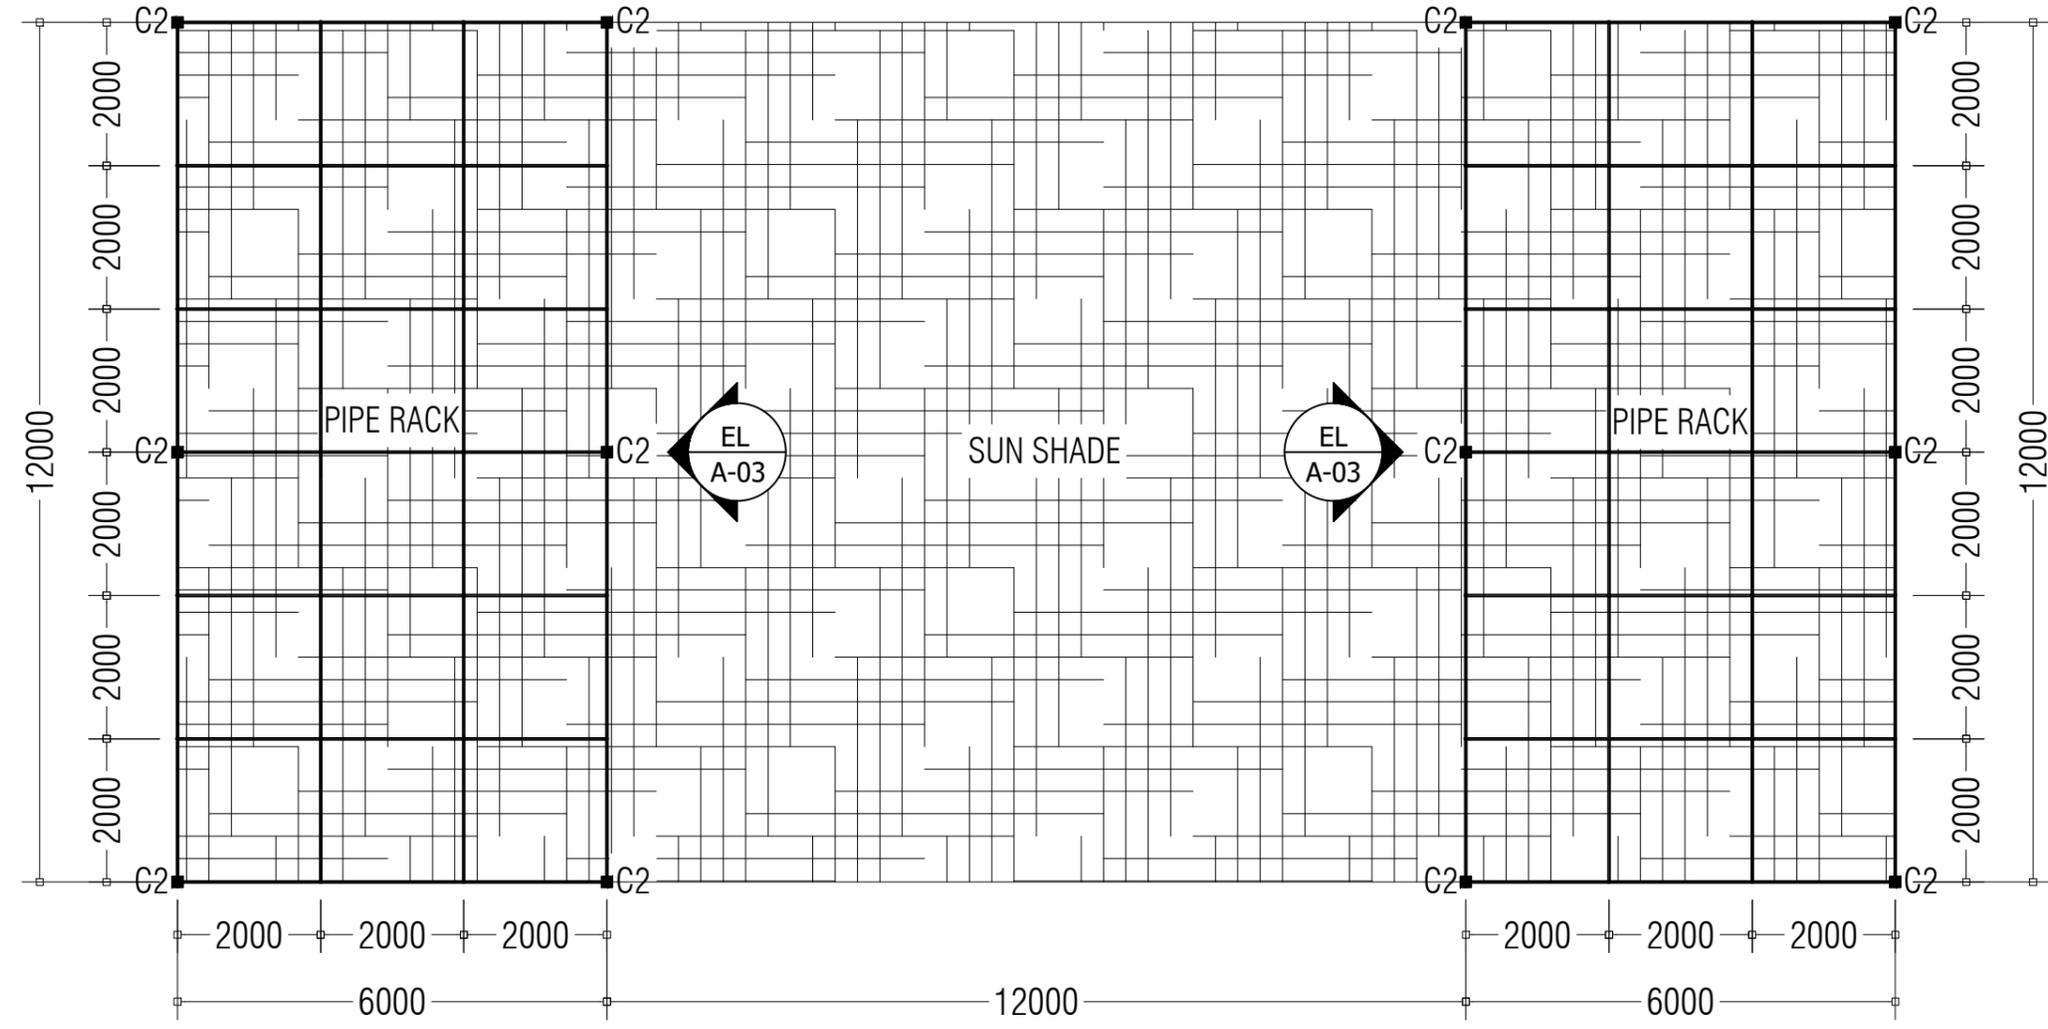

PIPE RACK LAYOUT  
SCALE NTS

DRAWN BY: FATHMATH FAZEELA

DRAWING TITLE: PIPE RACK LAYOUT

DRAWING NO: 25-E09-NILA-WS-A1-DD-09 PAGE NO: 09

SCALE: NTS REV NO: 00

DATE: 04th DECEMBER 2025 PAPER SIZE: A3

LOCATION: F.NILANDHOO

ARCHITECT  
/CHECKER  
STAMP:

STRUCTURAL  
ENGINEER  
/CHECKER  
STAMP:

ELECTRICAL  
ENGINEER  
/CHECKER  
STAMP:

| REV NO. | DATE | REVISION DESCRIPTION |
|---------|------|----------------------|
|         |      |                      |
|         |      |                      |

PROJECT TITLE:  
CONSTRUCTION OF DESIGN AND BUILD OF SEWERAGE FACILITIES AT F.NILANDHOO

SUB TITLE:  
SEWERAGE FACILITIES

CLIENT:  
MINISTRY OF CONSTRUCTION,  
HOUSING &  
INFRASTRUCTURE

CONTRACTOR:  
MALE WATER & SEWERAGE  
COMPANY PVT.LTD



DESIGN CONTRACTOR:  
MALE WATER & SEWERAGE  
COMPANY PVT.LTD



TYPE OF DRAWING: F.NILANDHOO TEMPORARY SITE

LEGENDS & NOTES:

DRAWN BY: FATHMATH FAZEELA

DRAWING TITLE: PIPE RACK ELEVATION

DRAWING NO: 25-E09-NILA-WS-D1-DD-10 PAGE NO: 10

SCALE: NTS REV NO: 00

DATE: 04th DECEMBER 2025 PAPER SIZE: A3

LOCATION: F.NILANDHOO


ARCHITECT /CHECKER STAMP:

STRUCTURAL ENGINEER /CHECKER STAMP:


ELECTRICAL ENGINEER /CHECKER STAMP:

| REV NO. | DATE | REVISION DESCRIPTION |
|---------|------|----------------------|
|         |      |                      |
|         |      |                      |


MWSC-C3-F-06 Rev00

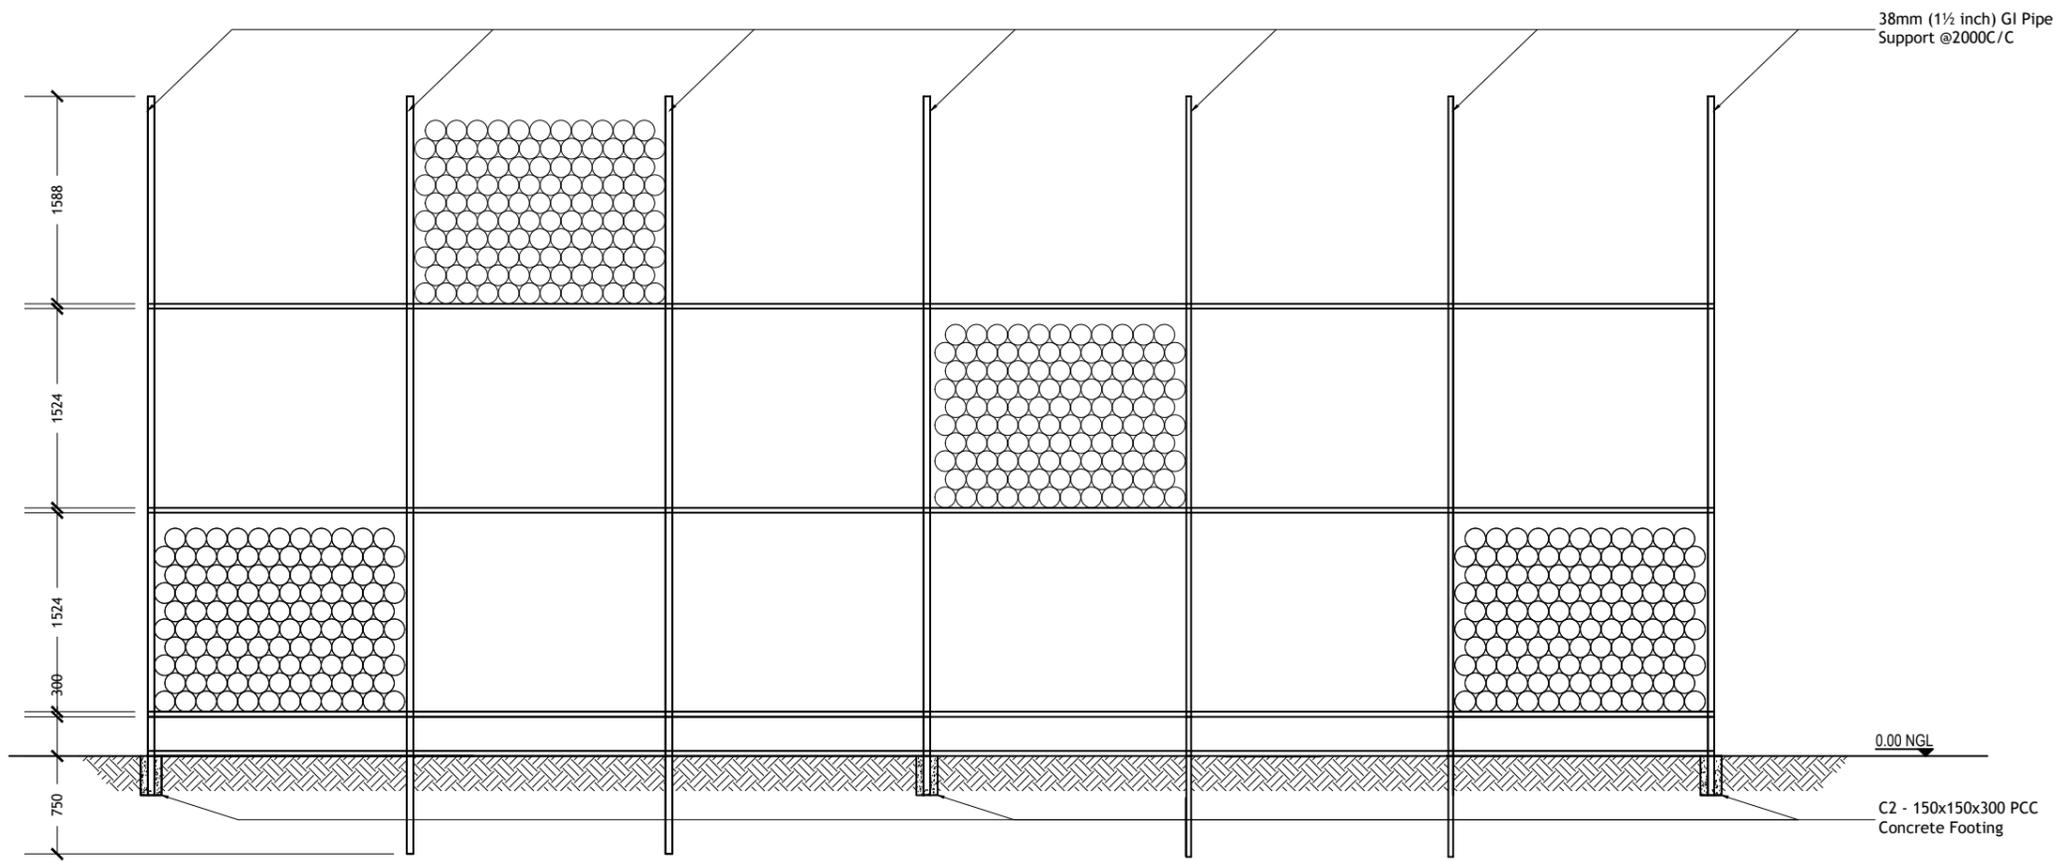


PIPE RACK - ELEVATION A03  
SCALE NTS

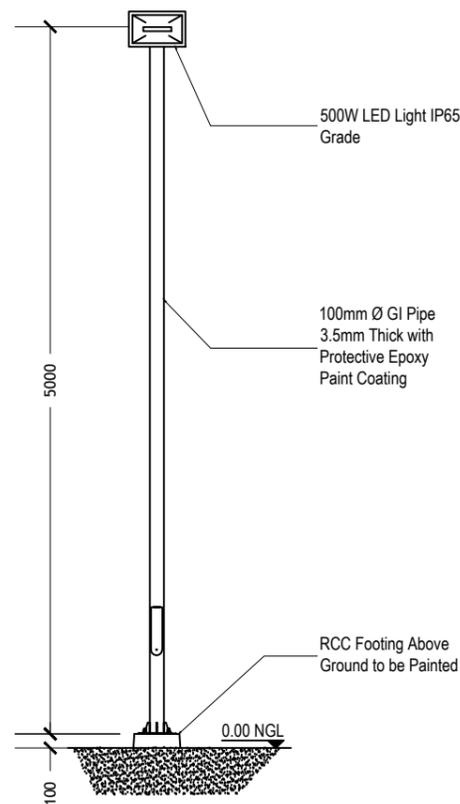


LIGHT POST - FRONT VIEW  
SCALE 1:50

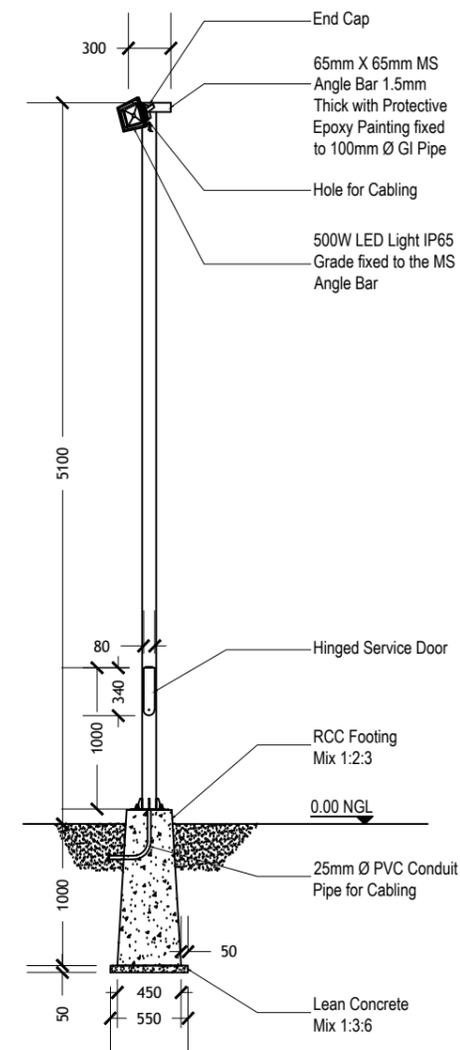

LIGHT POST DETAILS  
SCALE 1:50

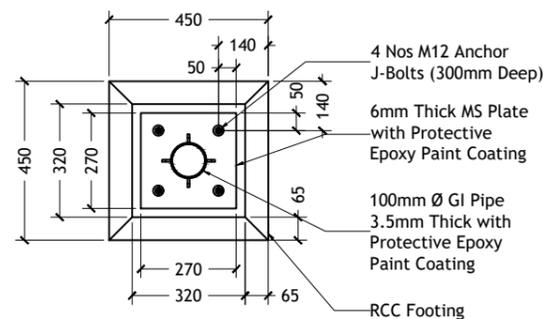

LIGHT POST - PLAN VIEW  
SCALE 1:20

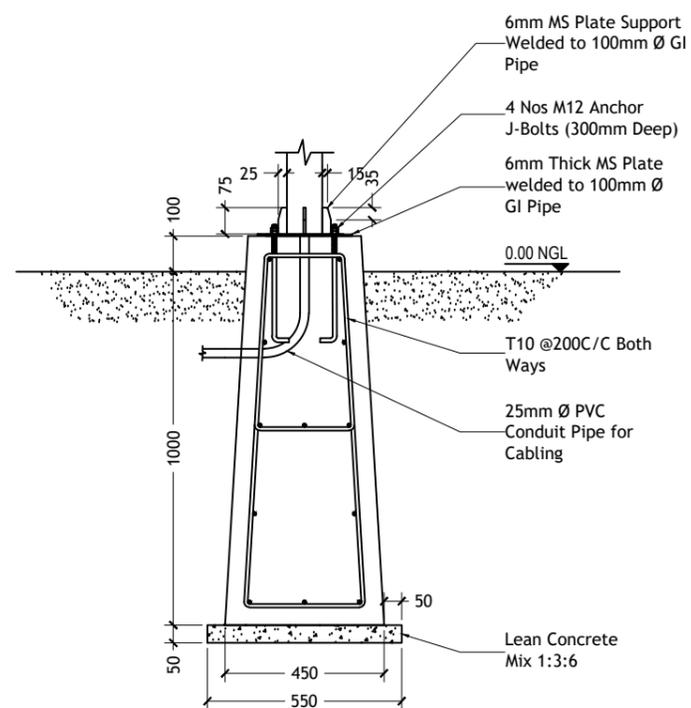

LIGHT POST - FOOTING DETAIL  
SCALE 1:20

PROJECT TITLE:  
CONSTRUCTION AND BUILD OF SEWERAGE  
FACILITIES AT F.NILANDHOO

SUB TITLE:  
SEWERAGE FACILITIES

CLIENT:  
MINISTRY OF CONSTRUCTION,  
HOUSING &  
INFRASTRUCTURE

CONTRACTOR:  
MALE WATER & SEWERAGE  
COMPANY PVT.LTD



DESIGN CONTRACTOR:  
MALE WATER & SEWERAGE  
COMPANY PVT.LTD



TYPE OF  
DRAWING: F.NILANDHOO TEMPORARY SITE

LEGENDS & NOTES:

DRAWN BY: FATHMATH FAZEELA

DRAWING TITLE: LIGHT POST DETAILS

DRAWING NO: 25-E09-NILA-WS-D1-DD-11 PAGE NO: 11

SCALE: AS GIVEN REV NO: 00

DATE: 04th DECEMBER 2025 PAPER SIZE: A3

LOCATION: F.NILANDHOO

ARCHITECT  
/CHECKER  
STAMP:

STRUCTURAL  
ENGINEER  
/CHECKER  
STAMP:

ELECTRICAL  
ENGINEER  
/CHECKER  
STAMP:

| REV NO. | DATE | REVISION DESCRIPTION |
|---------|------|----------------------|
|         |      |                      |
|         |      |                      |

PROJECT TITLE:  
CONSTRUCTION OF DESIGN AND BUILD OF SEWERAGE FACILITIES AT F.NILANDHOO

SUB TITLE:  
SEWERAGE FACILITIES

CLIENT:  
MINISTRY OF CONSTRUCTION,  
HOUSING &  
INFRASTRUCTURE

CONTRACTOR:  
MALE WATER & SEWERAGE  
COMPANY PVT.LTD



DESIGN CONTRACTOR:  
MALE WATER & SEWERAGE  
COMPANY PVT.LTD



TYPE OF DRAWING: F.NILANDHOO TEMPORARY SITE

LEGENDS & NOTES:  
 LIGHT SWITCH (1 GANG - 6 GANG)  
 LIGHT POST

DRAWN BY: FATHMATH FAZEELA

DRAWING TITLE: TEMPORARY SITE LIGHT POST LAYOUT

DRAWING NO: 25-09-NILA-WS-D1-DD-12 PAGE NO: 09

SCALE: NTS REV NO: 00

DATE: 04th DECEMBER 2025 PAPER SIZE: A3


LOCATION: F.NILANDHOO

ARCHITECT  
/CHECKER  
STAMP:

STRUCTURAL  
ENGINEER  
/CHECKER  
STAMP:

ELECTRICAL  
ENGINEER  
/CHECKER  
STAMP:

| REV NO. | DATE | REVISION DESCRIPTION |
|---------|------|----------------------|
|         |      |                      |
|         |      |                      |

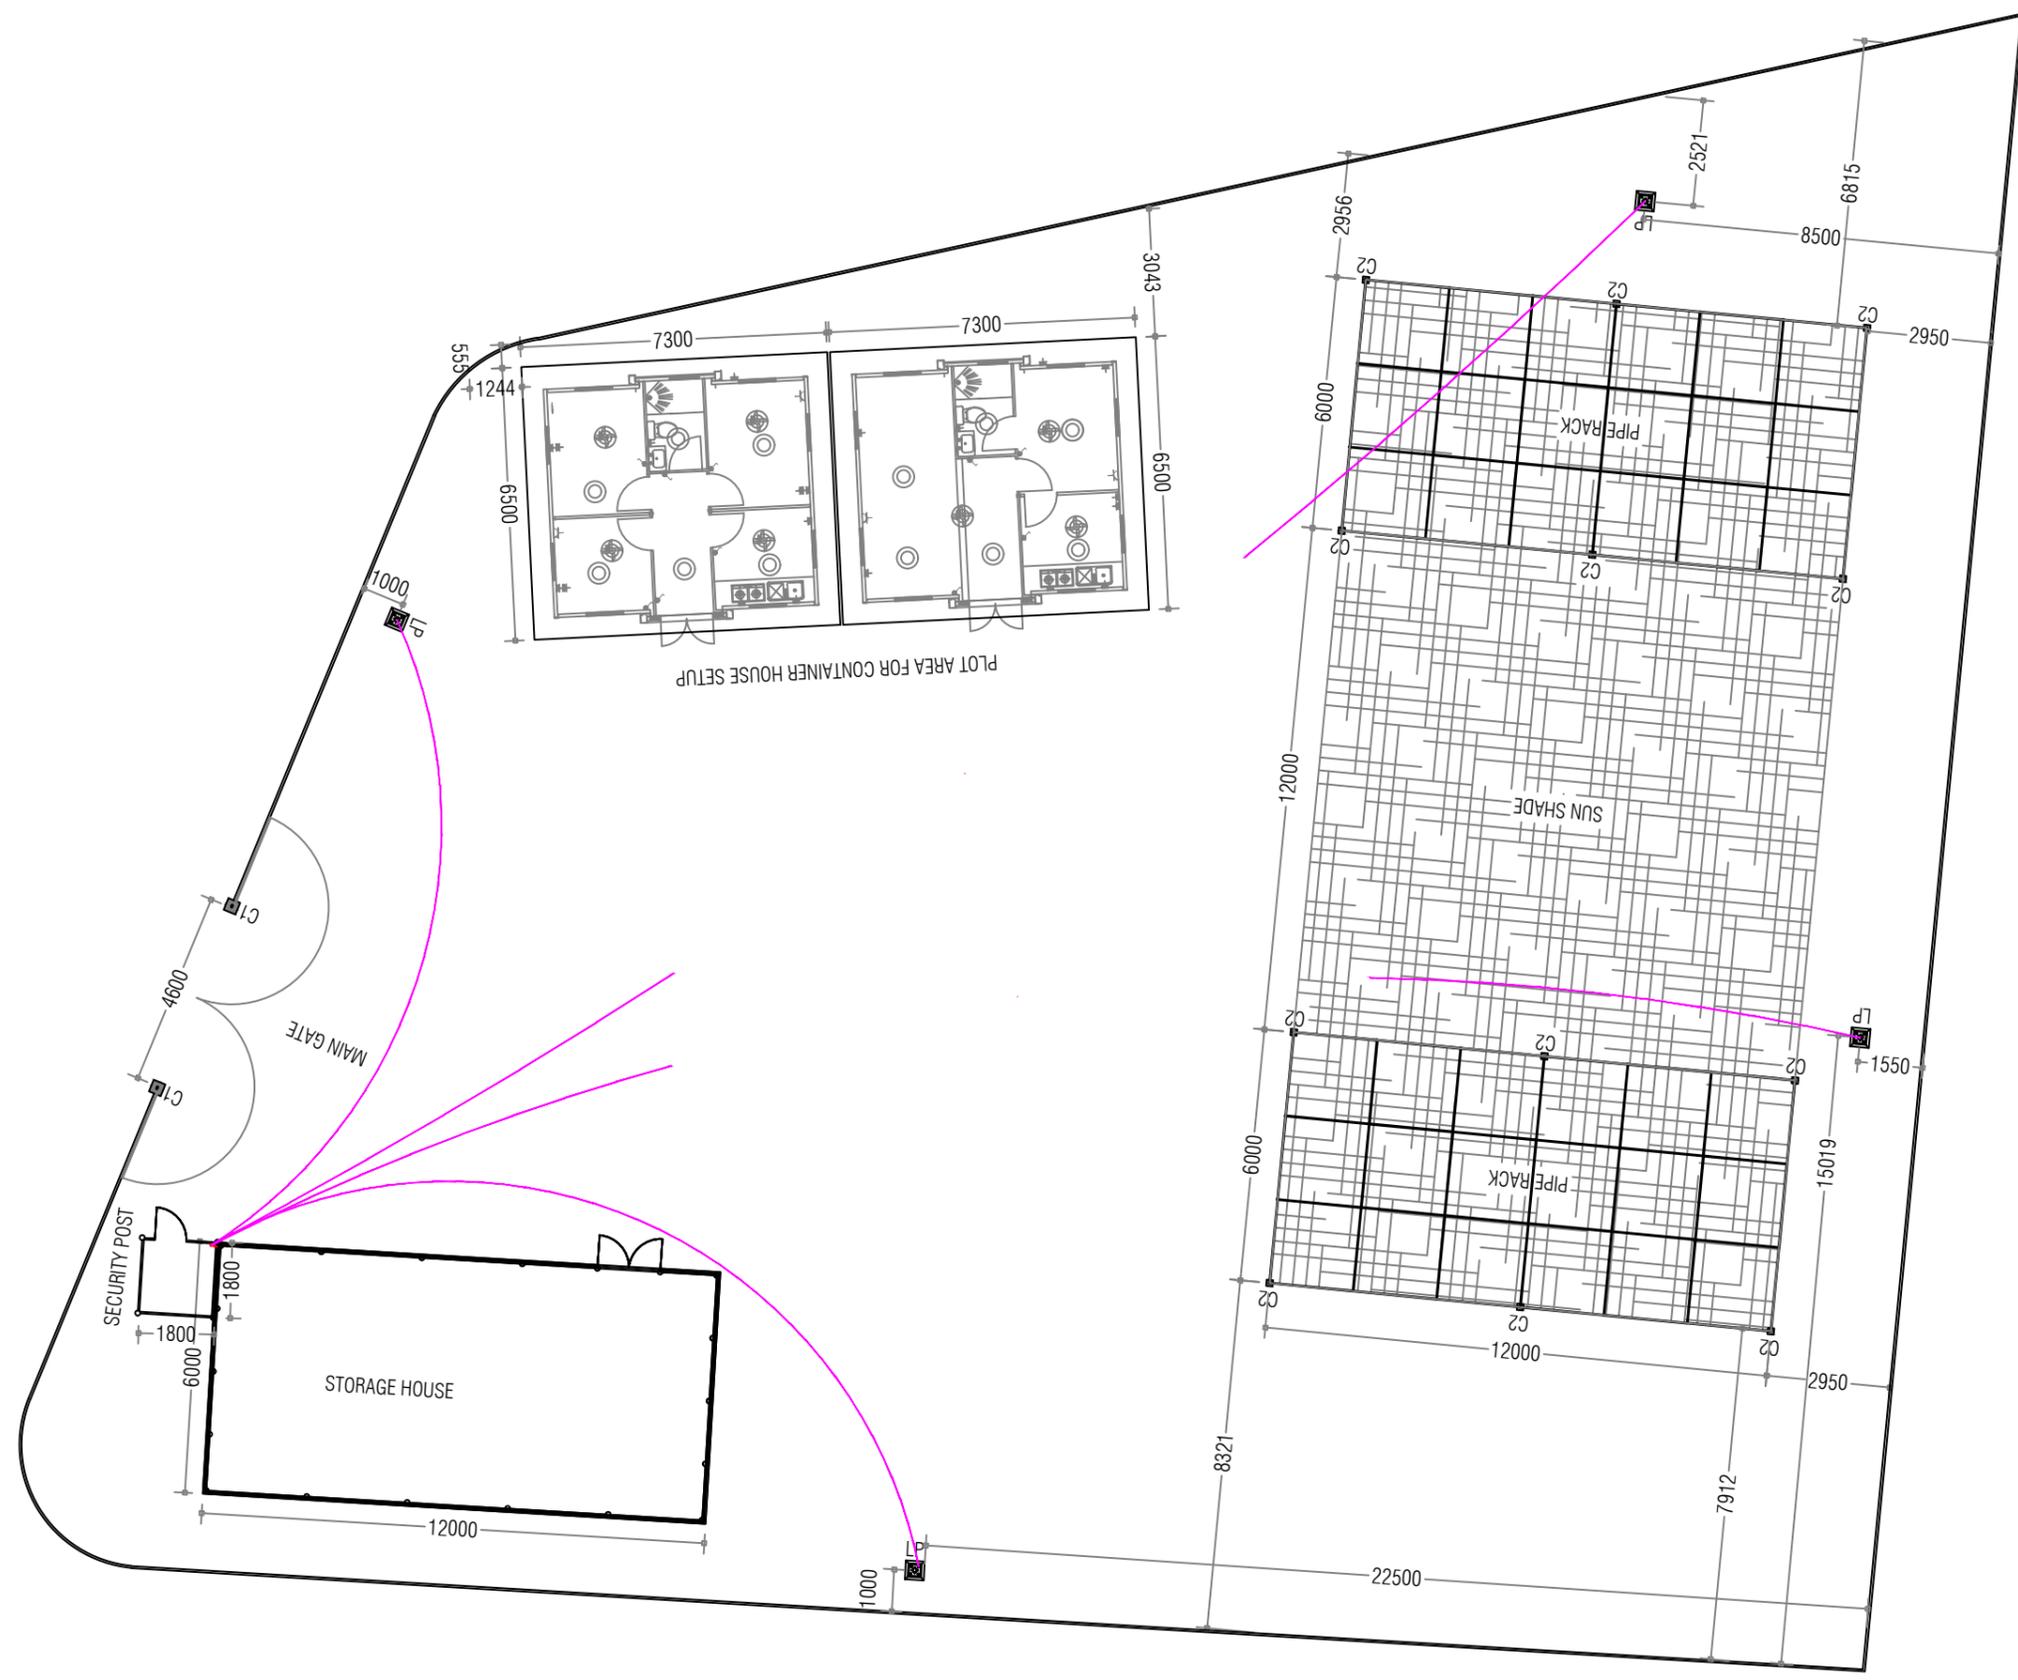

TEMPORARY SITE LIGHT POST LAYOUT  
SCALE NTS

SUMMARY OF BILLS OF QUANTITIES

**CONSTRUCTION OF TEMPORARY STORAGE SITE AT F.NILANDHOO**

BOQ Reference Number: BOQ/181

| DESCRIPTION   | AMOUNT (MVR) | %    |
|---|--------------|------|
| BILL NO. 01 - CONSTRUCTION OF TEMPORARY SITE                | -            |      |
| BILL NO. 02 - CABLE LAYING WORKS FOR TEMPORARY STORAGE SITE | -            |      |
| BILL NO. 03 - CONSTRUCTION OF LIGHT POST FOR TEMPORARY SITE | -            |      |
| BILL NO. 04 - ADDITION & OMISSION                           | -            |      |
|   |              |      |
| TOTAL AMOUNT  | -            |      |
|   |              |      |
| TOTAL DURATION:   | -            | Days |

## CONSTRUCTION OF TEMPORARY STORAGE SITE AT F.NILANDHOO

Male', Republic of Maldives

| SL.No      | Description   | Unit | Qty | Rate (MVR) | Total Amount (MVR) |
|------------|---|------|-----|------------|--------------------|
|            | <b>BILL NO. 01 - CONSTRUCTION OF TEMPORARY SITE</b>   |      |     |            |                    |
| <b>1.1</b> | <b>Discrepancies</b>  |      |     |            |                    |
|            | All participants in the Tender exercise are deemed to have read the Specifications and BOQ carefully in conjunction with all the Contract Drawings. Any discrepancies between these documents are to be brought to the attention of the Employer and clarified prior to the closing of the Tender. Should any said discrepancies be discovered at a later date, the decision of the Employer is final and any extra cost due to the contractor as a result of such discrepancies will NOT be entertained whatsoever. The Contractor shall, at all times, exercise with care and professional scrutiny to ensure that there are no discrepancies and/or divergence between Contract Drawings and specifications prior to execution of any portion of the Works on site. The Contractor shall immediately give the Employer a written notice specifying any such discrepancies or divergence should he discovered such issues and the Employer shall issue instructions in regard thereto. The Contractor should exercise due diligence in this matter as a failure and/or negligence in complying with the above stated requirements may result in extra costs. Any extra costs incurred in respect therefore shall be borne solely by the Contractor. |      |     |            |                    |
|            | Payment will be made within <b>45 days</b> upon submission of the invoice.  |      |     |            |                    |
|            | <b>ADVANCE PAYMENT</b> is not applicable for this work.   |      |     |            |                    |
| <b>1.2</b> | <b>GENERAL</b>  |      |     |            |                    |
|            | a The Bill of Quantities shall be read in conjunction with the Instruction to Bidders, General Conditions of Contract, Appendix to bid, Technical Specification and Tender Drawings.  |      |     |            |                    |
|            | b The rates and prices tendered in the priced Bill of Quantities shall, except in so far as it is otherwise provided under the Contract, include all constructional plant, labour, supervision, materials, transportation, installation/erection, profit, together with all general risks, liabilities and obligations set out or implied in the Contract.  |      |     |            |                    |
|            | c The rates and prices shall be quoted entirely in Maldivian Rufiyaa.   |      |     |            |                    |
|            | d A rate or price shall be entered against each item in the Bill of Quantities, whether quantities are stated or not. The cost of items against which the Contractor has failed to enter a rate or price shall be deemed to be covered by other rates and prices entered in the Bill of Quantities and no separate payment shall be made for such un-priced items.  |      |     |            |                    |
|            | e The whole cost of complying with the provisions of the Contract shall be included in the items provided in the priced Bill of Quantities, and where no items are provided but required for completion of contract works, the cost shall be deemed to be distributed among the rates and prices entered for the related item of work. Only properly executed variation orders shall be recognized for additional payment for items not entered in the Bill of Quantities.  |      |     |            |                    |
|            | f General directions and descriptions of work and materials are not necessarily repeated or summarized in the Bill of Quantities. The Bidder shall refer to relevant sections of the Contract Document to fully understand the item requirements before entering rates or prices against each item in the Bill of Quantities.   |      |     |            |                    |
|            | g All quantities have been rounded to the nearest whole number. Quantities less than one unit has been given as one unit. Measurement standard applied for calculation of quantities are according to NRM-2, RICS.  |      |     |            |                    |
|            | h <b>All the materials and equipment required for the works shall be arranged by the contractor. The materials shall be approved by MWSC before implementation.</b>   |      |     |            |                    |
|            | i <b>Rates shall include for all painting and finishing as specified. Rate shall include for painting and finishing of exposed surfaces of all steel members. Rate shall also include for application of redoxide at welding joints &amp; one coat of primer paint specific for metal applications. Rate shall also include for application of bitumastic paint on steel members embedded in concrete.</b>  |      |     |            |                    |
|            | j <b>Rates shall include for fabrication and erection and temporary supports and fixing in to position.</b>   |      |     |            |                    |
|            |   |      |     |            |                    |
|            | <u>Abbreviations</u>  |      |     |            |                    |
|            | m - metre   |      |     |            |                    |
|            | nr - numbers  |      |     |            |                    |
|            | m3 - cubic metres   |      |     |            |                    |

|  |  |                |       |  |   |
|--|--|----------------|-------|--|---|
| m2 -   | square metres  |                |       |  |   |
| lm -   | linear metre   |                |       |  |   |
| t -  | tons   |                |       |  |   |
| inc. -   | including  |                |       |  |   |
| mm -   | millimetre   |                |       |  |   |
| SS -   | stainless steel  |                |       |  |   |
| GI -   | galvanized iron  |                |       |  |   |
| Kg -   | kilogram   |                |       |  |   |
| <b>1.3 CONSTRUCTION OF TEMPORARY SITE</b>                          |  |                |       |  |   |
| <b>1.3.1 Site Clearance</b>  |  |                |       |  |   |
| a.   | Site clearing including filling, levelling and compaction. Rate shall include for relocation, replantation & disposal of site clearance debris as per ERA requirements. Rate shall also include for cleaning upon completion.  | m <sup>2</sup> | 1,613 |  | - |
| <b>1.3.2 Security Post</b>   |  |                |       |  |   |
| a.   | Construction of security guard post 1.8m x 1.8m as per drawing and specification. Rates shall include all materials required to complete the works and electrical work. Rate shall include for supply & installation of ceiling fan & light with switches, wiring and electrical board (complete setup) as per specification and instruction given by the Engineer | item           | 1     |  | - |
| <b>1.3.3 Material Store</b>  |  |                |       |  |   |
| a.   | Construction of Material Store post 6m x 12m as per drawing and specification. Rates shall include all materials required to complete the works and electrical works. Rate shall include for supply & installation of lights with switches, wiring and electrical board (complete setup) as per specification and instruction given by the Engineer                | item           | 1     |  | - |
| <b>1.3.4 Pipe Rack</b>   |  |                |       |  |   |
| a.   | Construction of Pipe Rack and sun shade net over the pipe rack as per drawing and specification. Rates shall include all materials required to complete the works.   | item           | 2     |  | - |
| <b>1.3.5 Sun Shade Net cover area</b>                              |  |                |       |  |   |
| a.   | Construction of Sun shade net over the area of 24m x 12m as per drawing and specification. Rates shall include all materials required to complete the works.   | item           | 1     |  | - |
| <b>1.3.6 Boundary Fence and Gate</b>                               |  |                |       |  |   |
| a.   | Construction of Boundary fence as per drawing and specification. Rates shall include all materials required to complete the works  | LM             | 150   |  | - |
| b.   | Construction of gate as per drawing and specification. Rates shall include all materials required to complete the works  | item           | 1     |  | - |
| END OF BILL NO 01: CARRIED OVER TO SUMMARY                         |  |                |       |  |   |
| <b>BILL NO. 02 - CABLE LAYING WORKS FOR TEMPORARY STORAGE SITE</b> |  |                |       |  |   |
| <b>2.1 GENERAL</b>   |  |                |       |  |   |
| a.   | Rates shall include for: screws, nails, bolts, nuts, standard cable fixing or supporting clips, brackets, straps, rivets, plugs and all incidental accessories   |                |       |  |   |
| b.   | Rates for work in trench shall include for: excavation, maintaining faces of excavations, backfilling, compaction, appropriate cable covers, warning tape and disposal of surplus spoil  |                |       |  |   |
| c.   | Cable laying item rate shall include for installation of warning tapes etc..   |                |       |  |   |
| d.   | The contractor is responsible for any damages to the cables and equipment such as panel boards, other utility service lines, surrounding structures, etc. during the pipe laying. The contractor shall indemnify the respective party against all losses or claims.  |                |       |  |   |
| e.   | Contractor shall arrange water & electricity for the project at his own expenses.  |                |       |  |   |
| f.   | Rate shall include mobilization, site management, materials, labor, water, electricity, site clearance, leveling, cleaning, disposal, demobilization, vehicles, vessels, permits, equipment, and tools including all necessary transport and storage required for proper execution and completion of works.  |                |       |  |   |
| g.   | The contractor shall take delivery and complete installation.  |                |       |  |   |

|  |   |      |       |  |      |
|--|---|------|-------|--|------|
|  | For Meter installation, the Rate shall include the following items but not be limited to;<br>- Electric Cables 2C x 6Sqmm<br>- Electrical Smart House Meter 60A-5 (FENAKA Approved)<br>- MCB 32A (2 Pole)<br>- ELCB40A (2 Pole)<br>- CB Box (2Pole)<br>h. - Socket Switch 13A (Box Included)<br>- Socket Switch 15A (Box Included)<br>- Earth Rod<br>- Earth Clamp<br>- Earth Wire 6sqmm<br>- Junction 8"x8"<br>- Warning Tapes |      |       |  |      |
| <b>2.2</b>   | <b>Cable Laying works including meter installation &amp; electricity connection (Single Phase)</b>  |      |       |  |      |
| 2.2.1  | Excavation, Laying, and Backfilling of Power Cable, size: 2C x 6sqmm  | m    | 60.00 |  | -    |
| 2.2.2  | Supply and Installation of Electrical Smart Meter, Earth Rod, including connection from Meter to DB and all other ancillaries as per the Island Service provider requirement  | item | 1.00  |  | -    |
| END OF BILL NO 02: CARRIED OVER TO SUMMARY                         |   |      |       |  |      |
| <b>BILL NO. 03 - CONSTRUCTION OF LIGHT POST FOR TEMPORARY SITE</b> |   |      |       |  |      |
| <b>3.1</b>   | <b>GENERAL</b>  |      |       |  |      |
| a.   | Rates shall include for: screws, nails, bolts, nuts, standard cable fixing or supporting clips, brackets, straps, rivets, plugs and all incidental accessories  |      |       |  |      |
| b.   | Rates for work in trench shall include for: excavation, maintaining faces of excavations, backfilling, compaction, appropriate cable covers, warning tape and disposal of surplus spoil   |      |       |  |      |
| c.   | Cable laying item rate shall include for installation of warning tapes etc..  |      |       |  |      |
| d.   | The contractor is responsible for any damages to the cables and equipment such as panel boards, other utility service lines, surrounding structures, etc. during the pipe laying. The contractor shall indemnify the respective party against all losses or claims.   |      |       |  |      |
| e.   | Contractor shall arrange water & electricity for the project at his own expenses.   |      |       |  |      |
| f.   | Rate shall include mobilization, site management, materials, labor, water, electricity, site clearance, leveling, cleaning, disposal, demobilization, vehicles, vessels, permits, equipment, and tools including all necessary transport and storage required for proper execution and completion of works.   |      |       |  |      |
| g.   | The contractor shall take delivery and complete installation. Rates shall include for supply and complete installation , fittings and fixtures.   |      |       |  |      |
| h.   | Lighting fixture and electrical wires and other electrical equipment such as fans and such shall comply with STELCO/FENAKA/MEA standard and all fixtures and fitting shall be subjected to written approval by the client   |      |       |  |      |
| <b>3.2</b>   | <b>Construction of light post</b>   |      |       |  |      |
| 3.2.1  | 500W LED Flood Light IP65 @ 5m Light Post including footing and light post as per drawing   | Nos  | 4     |  | 0.00 |
| 3.2.2  | Light Switch - 4 Gang   | Nos  | 1     |  | 0.00 |
| 3.2.3  | 2.5mm2 Wiring to Light Points   | Nos  | 4     |  | 0.00 |
| END OF BILL NO 03: CARRIED OVER TO SUMMARY                         |   |      |       |  |      |
| <b>BILL NO. 04 - ADDITION &amp; OMISSION</b>                       |   |      |       |  |      |
| <b>4.1</b>   | <b>ADDITION</b>   |      |       |  |      |
| 4.1.1  | BILL NO. 01 - CONSTRUCTION OF TEMPORARY SITE  | Item |       |  | -    |
| 4.1.2  | BILL NO. 02 - CABLE LAYING WORKS FOR TEMPORARY STORAGE SITE   | Item |       |  | -    |
| 4.1.3  | BILL NO. 03 - CONSTRUCTION OF LIGHT POST FOR TEMPORARY SITE   | Item |       |  | -    |
| <b>4.2</b>   | <b>OMISSION</b>   |      |       |  |      |
| 4.2.1  | BILL NO. 01 - CONSTRUCTION OF TEMPORARY SITE  | Item |       |  | -    |
| 4.2.2  | BILL NO. 02 - CABLE LAYING WORKS FOR TEMPORARY STORAGE SITE   | Item |       |  | -    |
| 4.2.3  | BILL NO. 03 - CONSTRUCTION OF LIGHT POST FOR TEMPORARY SITE   | Item |       |  | -    |
| END OF BILL NO 04: CARRIED OVER TO SUMMARY                         |   |      |       |  |      |

Duration:  Days